




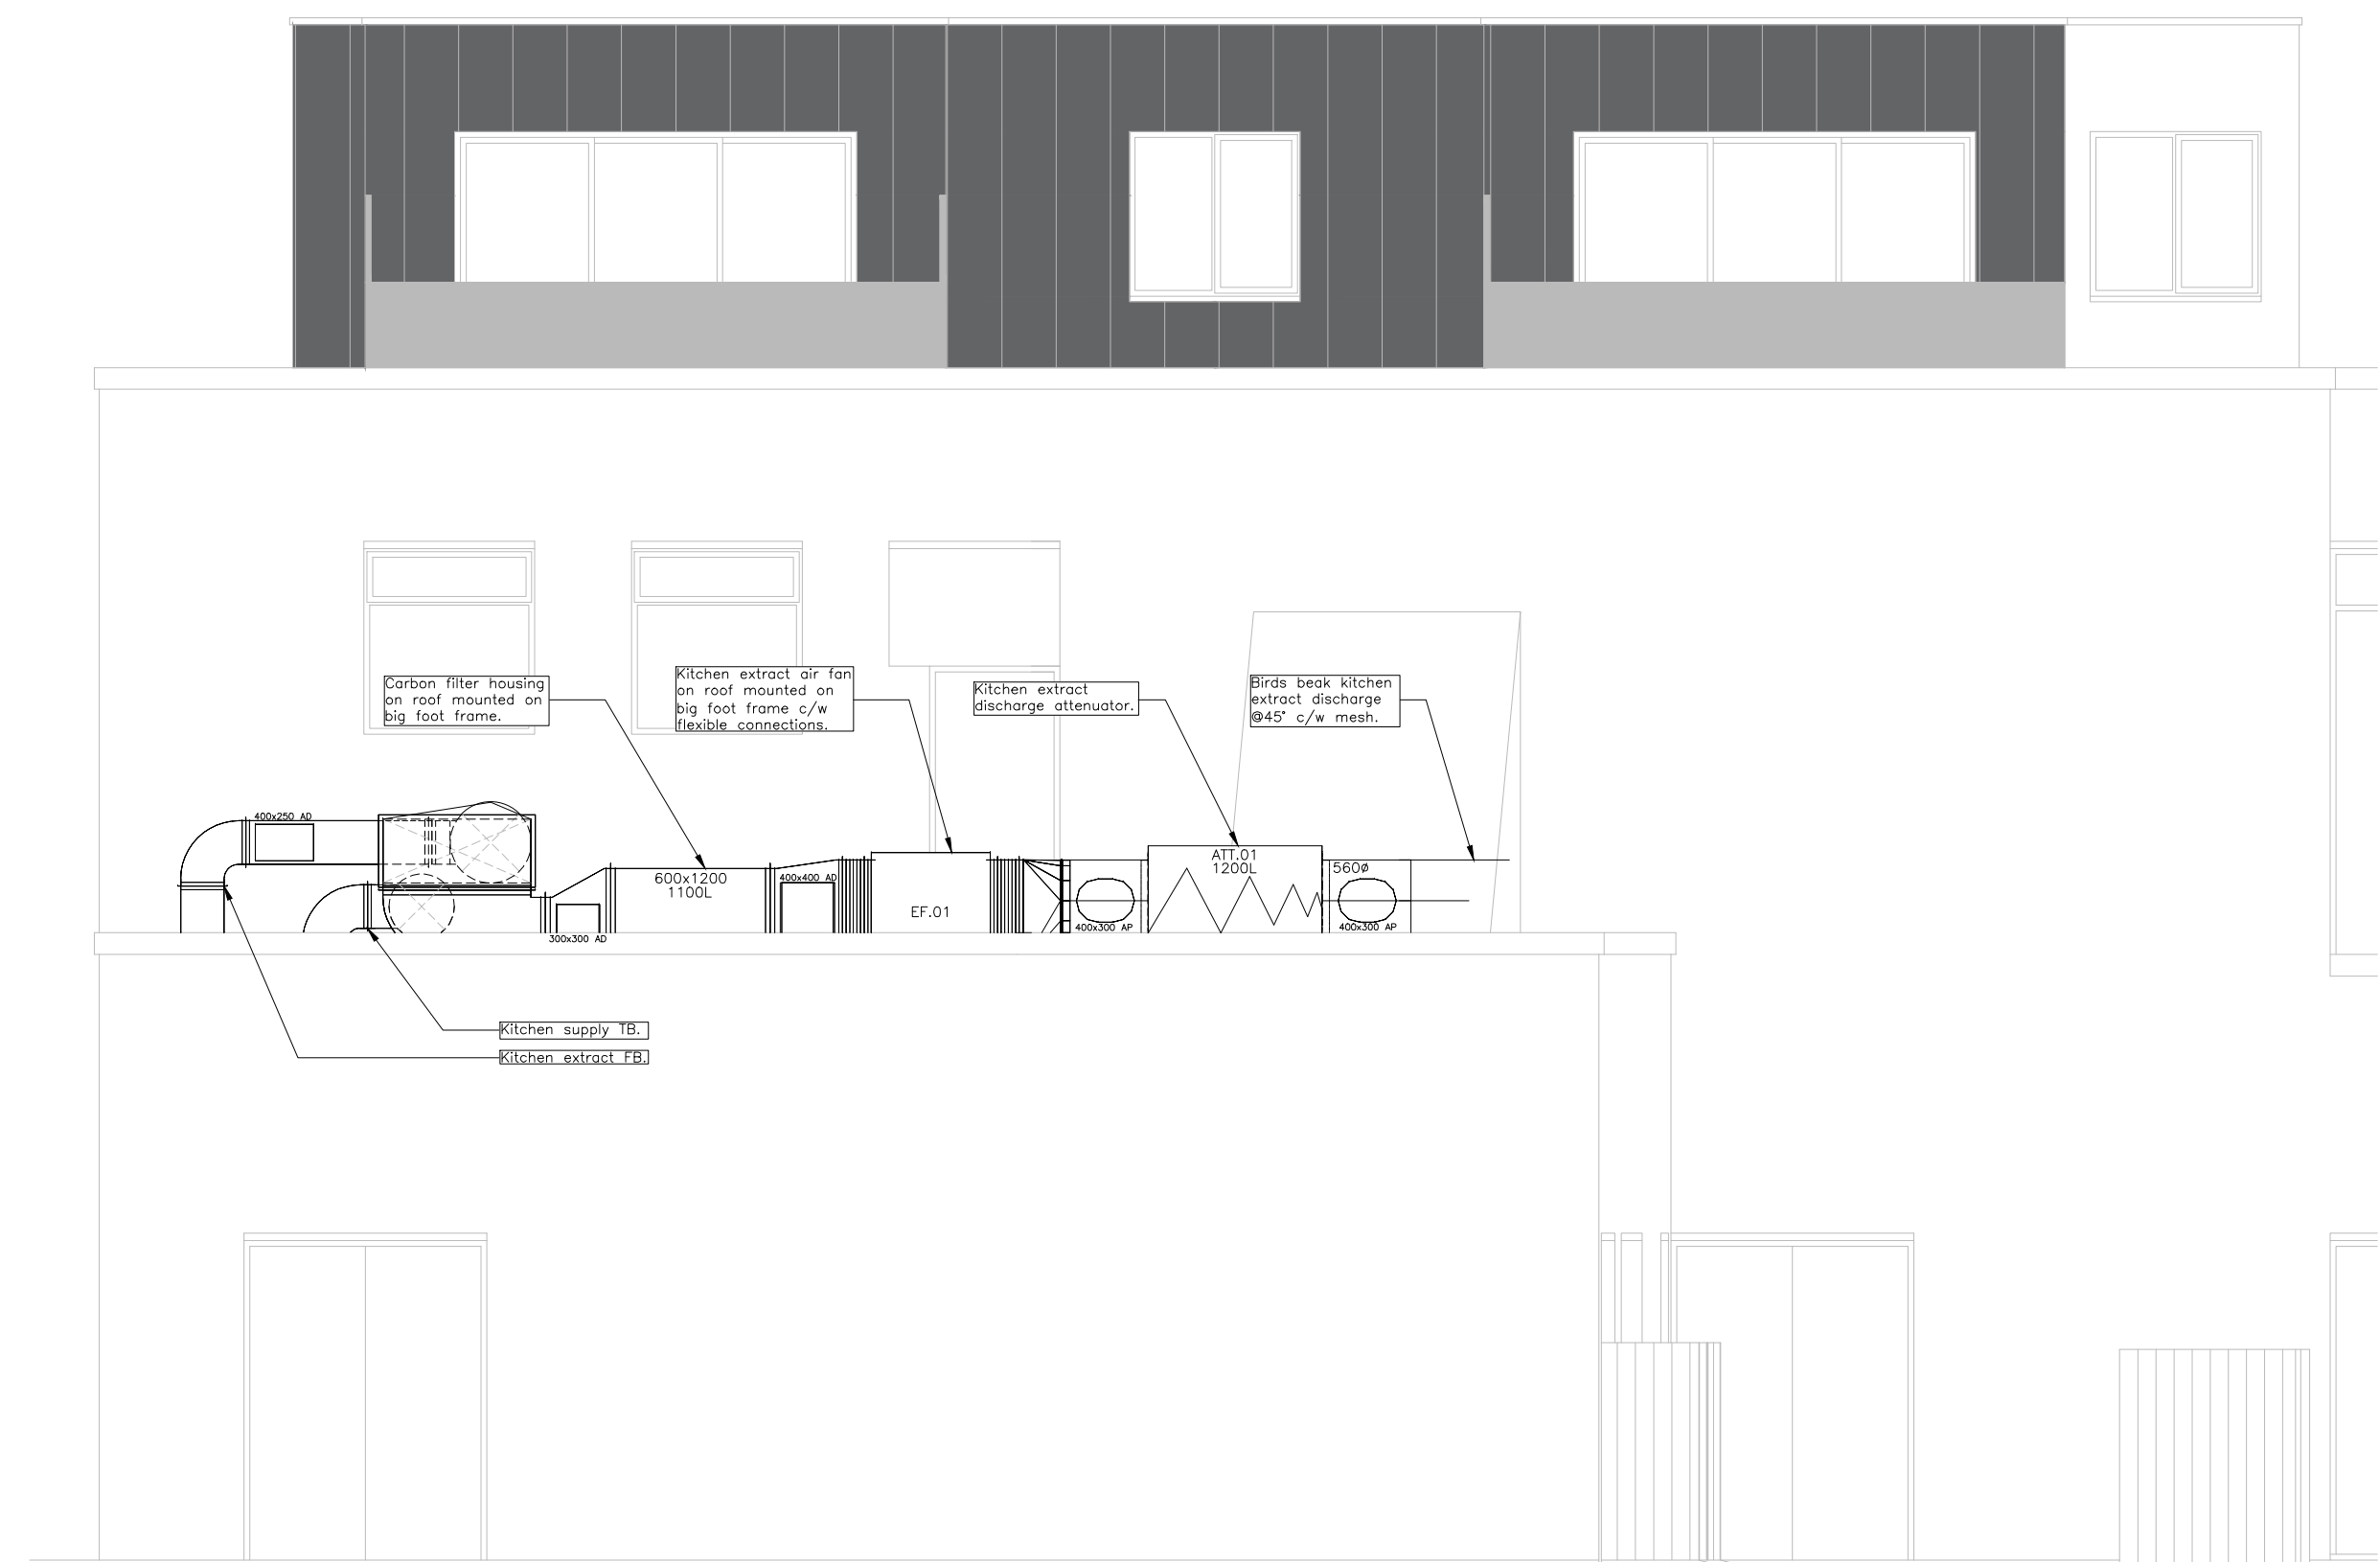


Proposed Rear Elevation (South)

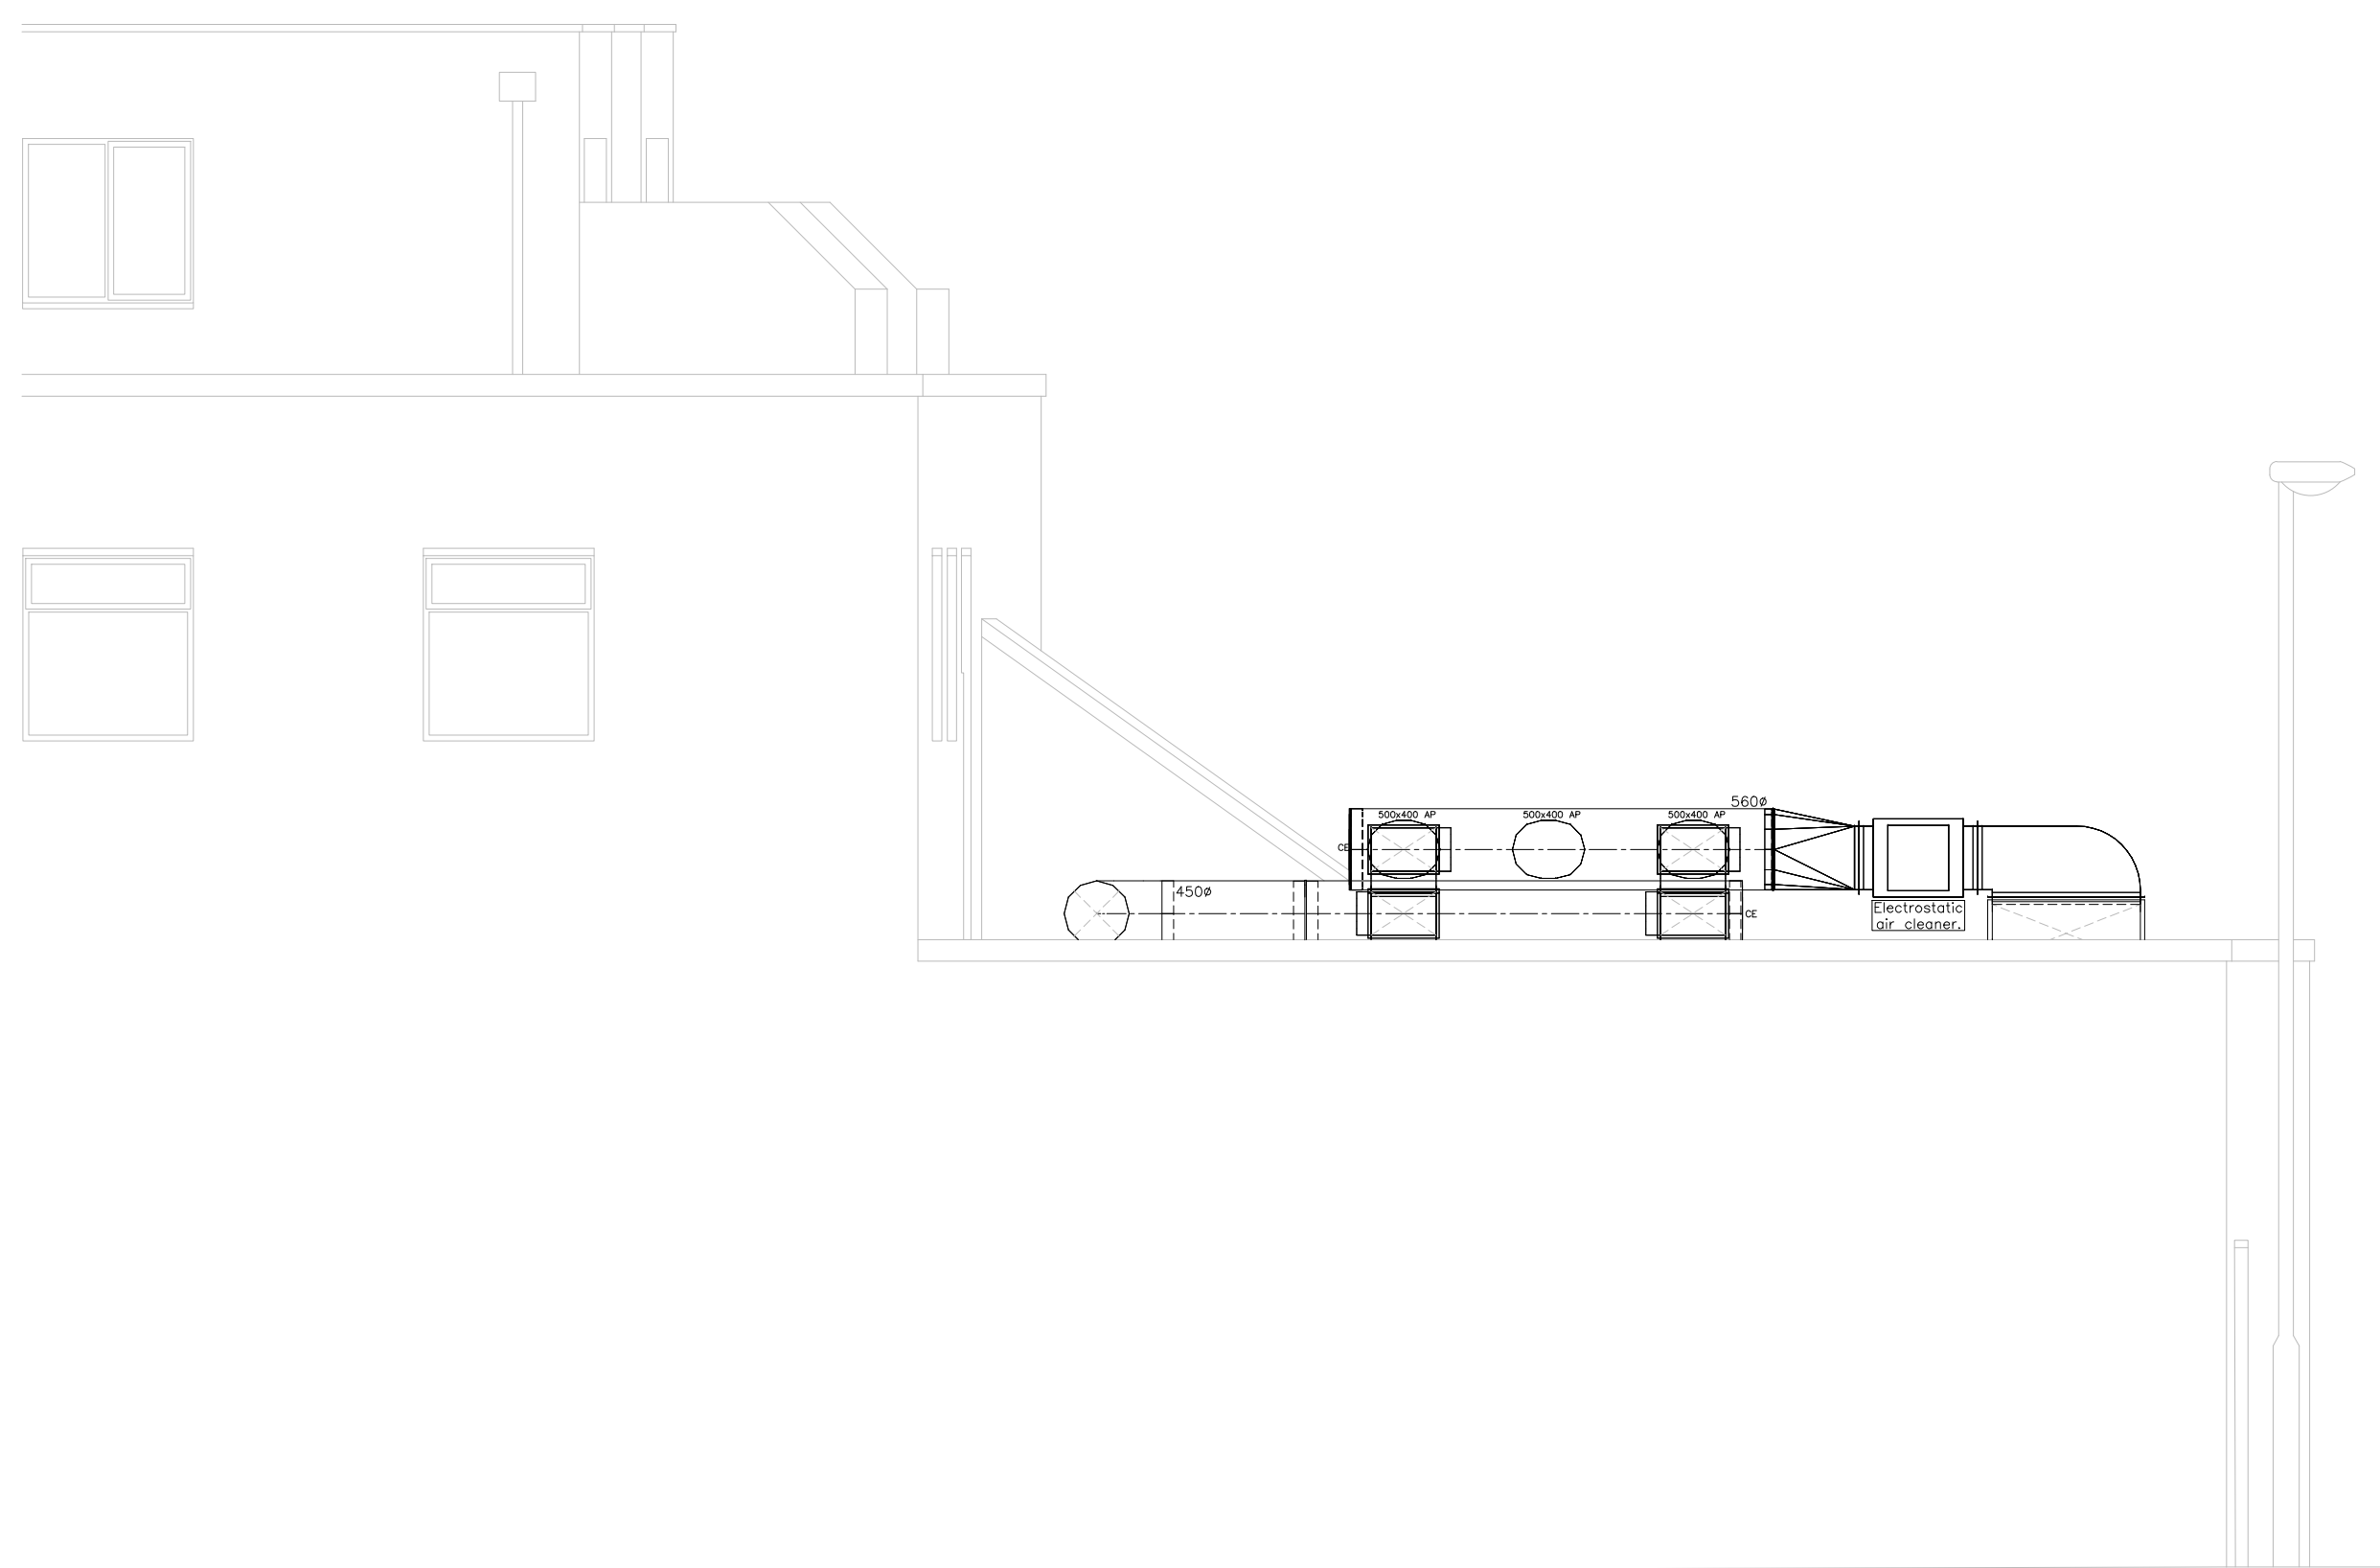

Proposed Side Elevation (West)

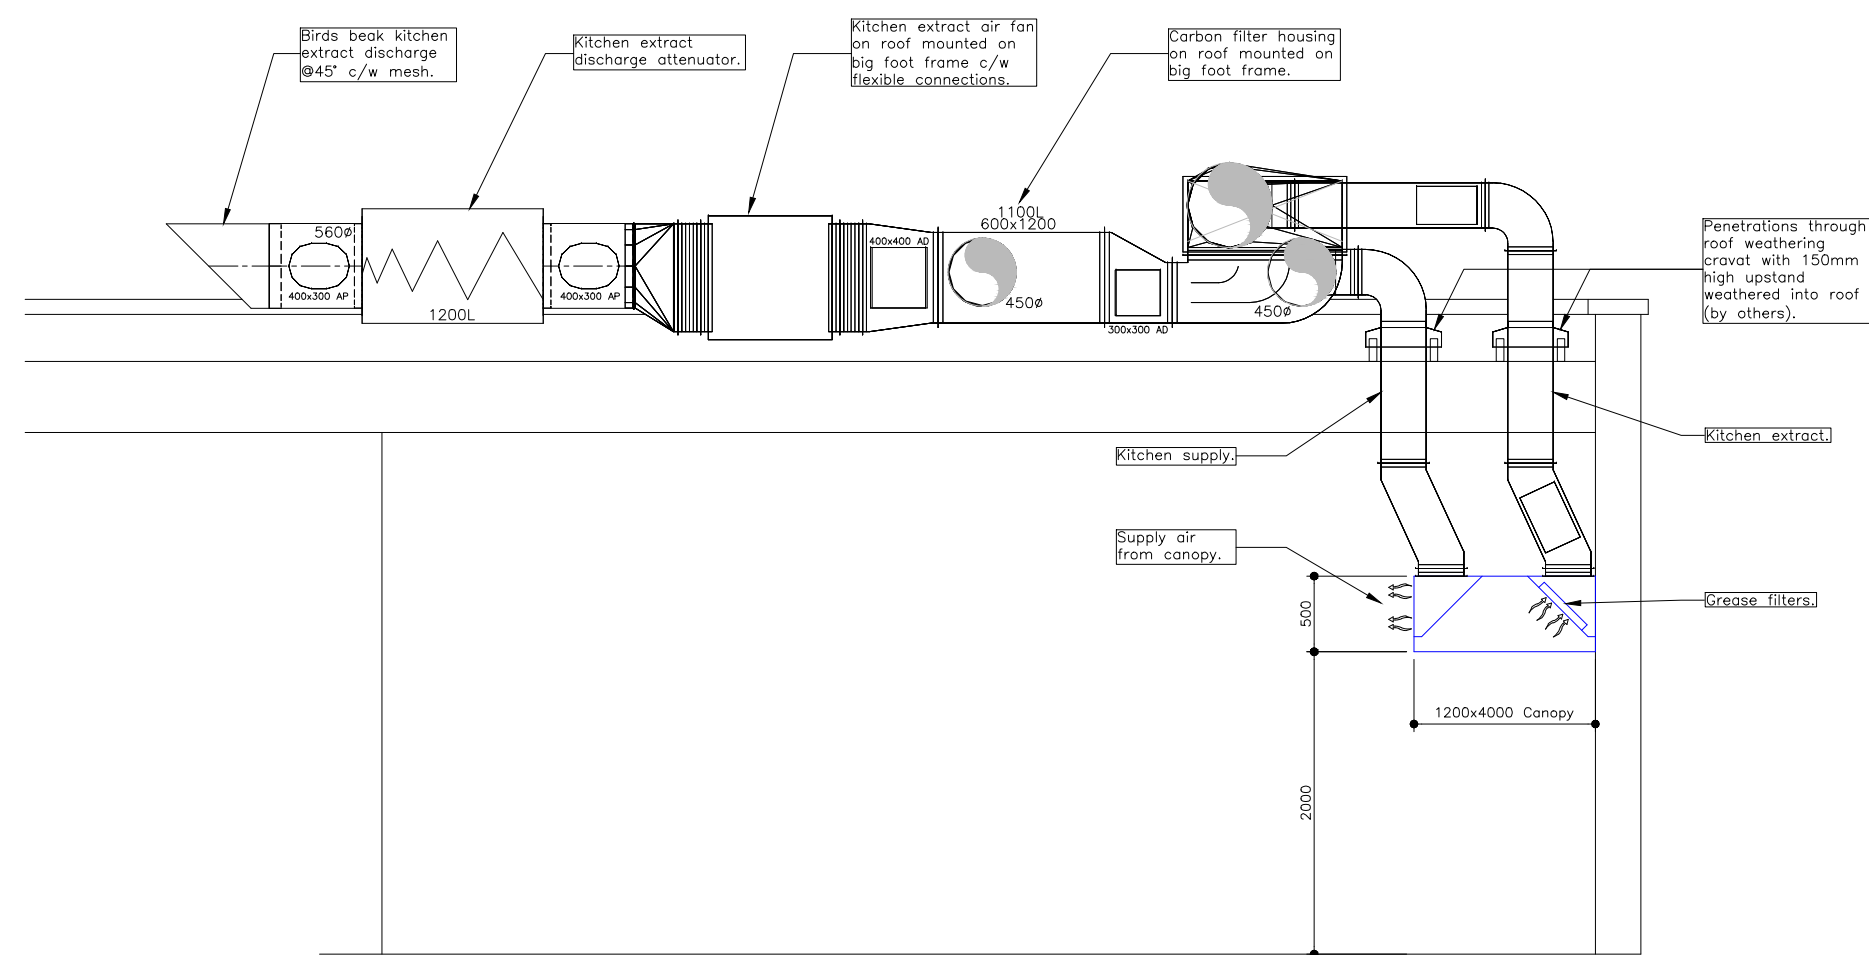

SECTION A-A
1:50

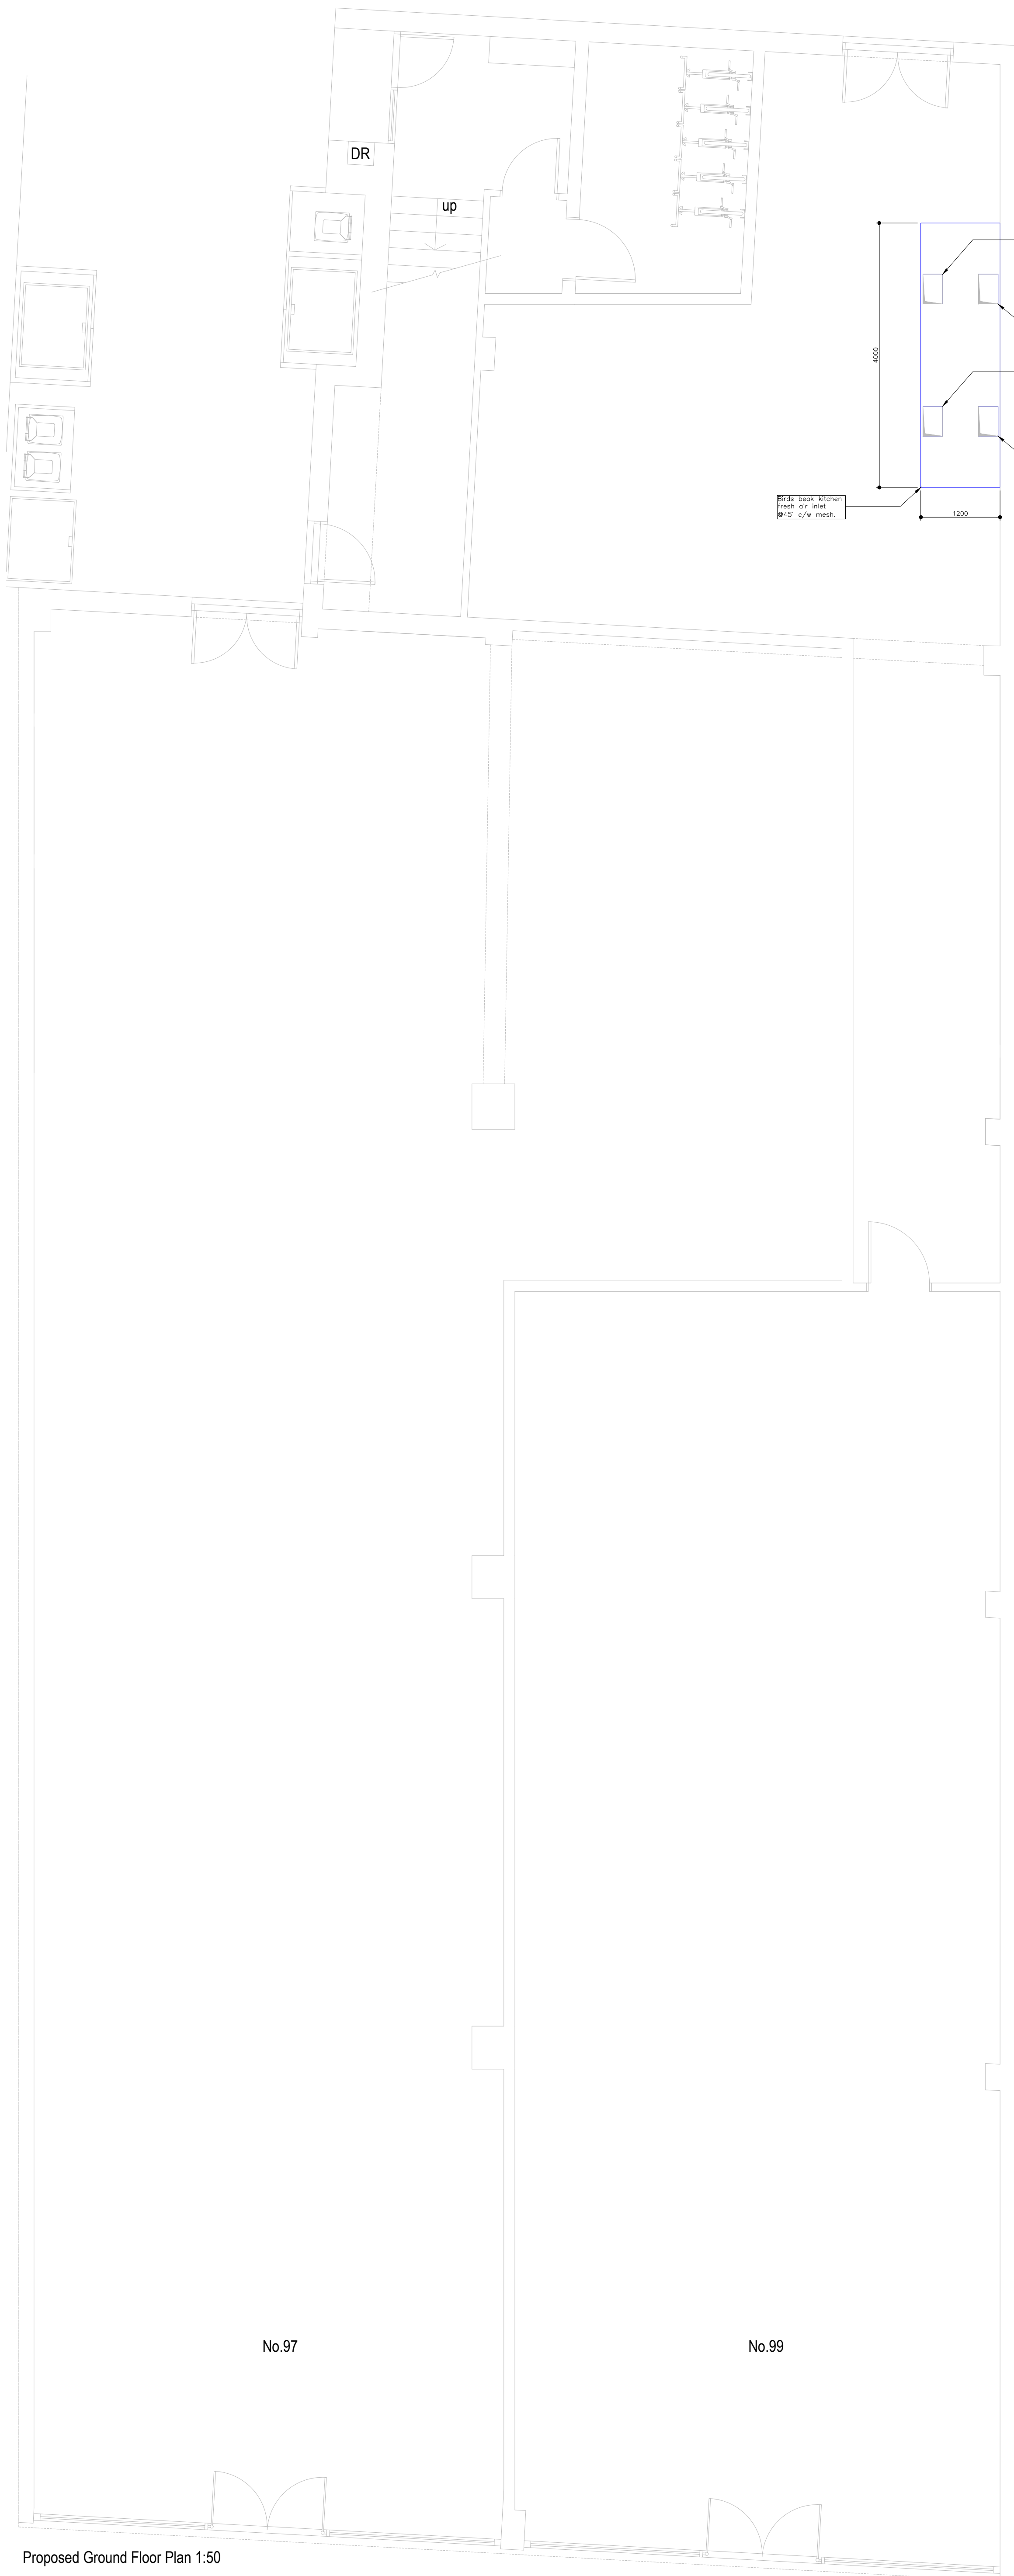

Proposed Ground Floor Plan 1:50



Proposed First Floor Plan 1:50

ALL VENTILATION & EXTRACTION (AVE) LTD. OWNS THE COPYRIGHT OF THIS DRAWING WHICH MUST NOT BE REPRODUCED WITHOUT THE WRITTEN PERMISSION OF THE OWNERS.

NOTES:

1. ALL DIMENSIONS IN MILLIMETRES.
2. DO NOT SCALE FROM THE DRAWING.
3. ALL DIMENSIONS TO BE VERIFIED ON SITE.
4. ALL DUCTWORK TO BE MANUFACTURED AND INSTALLED TO DIN144.
5. ALL OPEN ENDS TO BE BAGGED OFF DURING THE INSTALLATION TO PREVENT THE INGRESS OF DIRT.
6. ALL PRIMARY SUPPLY AND EXTRACT DUCTWORK TO HAVE NEOPRENE SPACERS OR BRACKETS.
7. ALL TOILET EXTRACT DUCTWORK TO HAVE NEOPRENE SPACER ON BRACKETS.
8. ALL FIRE DAMPERS TO BE INSTALLED AS PER MANUFACTURERS INSTALLATION DETAIL.
9. FIRE RATED DUCTWORK TO BE INSTALLED AS PER MANUFACTURERS INSTALLATION DETAIL.
10. ALL MATHS SUPPORTED ON W10 STUDING.
11. REC. SCALES ARE NOT TO BE USED ON FIRE DAMPERS OR WITHIN 1M OF ACCESS OPENINGS.

LEGEND:

- AD - ACCESS PANEL
- AE - ACCESS DOOR
- CE - CAP END
- DE - DUCT END
- FE - FLAT TOP TAPER
- LE - LARGE END
- FTT - FLAT TOP TAPER
- SU - SET UP
- SD - SET DOWN
- FD - FIRE DAMPER
- MSD - MOTORISED SMOKE FIRE DAMPER
- VCD - VOLUME CONTROL DAMPER
- MVCD - MOTORISED VCD
- BD - BLIND DAMPER
- SBD - SINGLE BLADE DAMPER
- FOC - COMBINED VOLUME CONTROL / FIRE DAMPER
- FOT - FLAT TOP CONNECTION
- FOB - FLAT BOTTOM CONNECTION
- CONNECTION - CONNECTION
- CTS - CUT TO SUIT
- REF - REFERENCE POINT
- ROD - INVERT LEVEL TO BOTTOM OF RECTANGULAR DUCTWORK
- CL - INVERT LEVEL TO CENTRE OF ROUND DUCTWORK
- BOU - FROM NOTED DATUM
- NRD - INVERT LEVEL TO BOTTOM OF FOU FROM NOTED DATUM
- FOU - FROM NOTED DATUM
- NRD - NON RETURN DAMPER

ALL INVERT LEVELS ARE TAKEN FROM FIRST FINISHED FLOOR LEVEL.

P01	19.05.2026	Updated to comments. Issued for approval.
P00	15.05.2026	Issued for comment.

Rev	Date	Description
-----	------	-------------



Unit 7 - Avoncot Trading Estate - Victoria Gardens -
ast Sussex Hill - West Sussex - BN15 9HJ
01464 236010 • sales@ave-ltd.com • ave-ltd.com

Project:
**97-99 Montague Street
Worthing
West Sussex
BN11 3BN**

Description:

**Proposed Kitchen
Ventilation Layout.**

Drawn:	Scale:	Date:
MRK	1:50@AO	May 2026
Drawing Number:	Revision:	
C7103-DW-00-001	P01	