


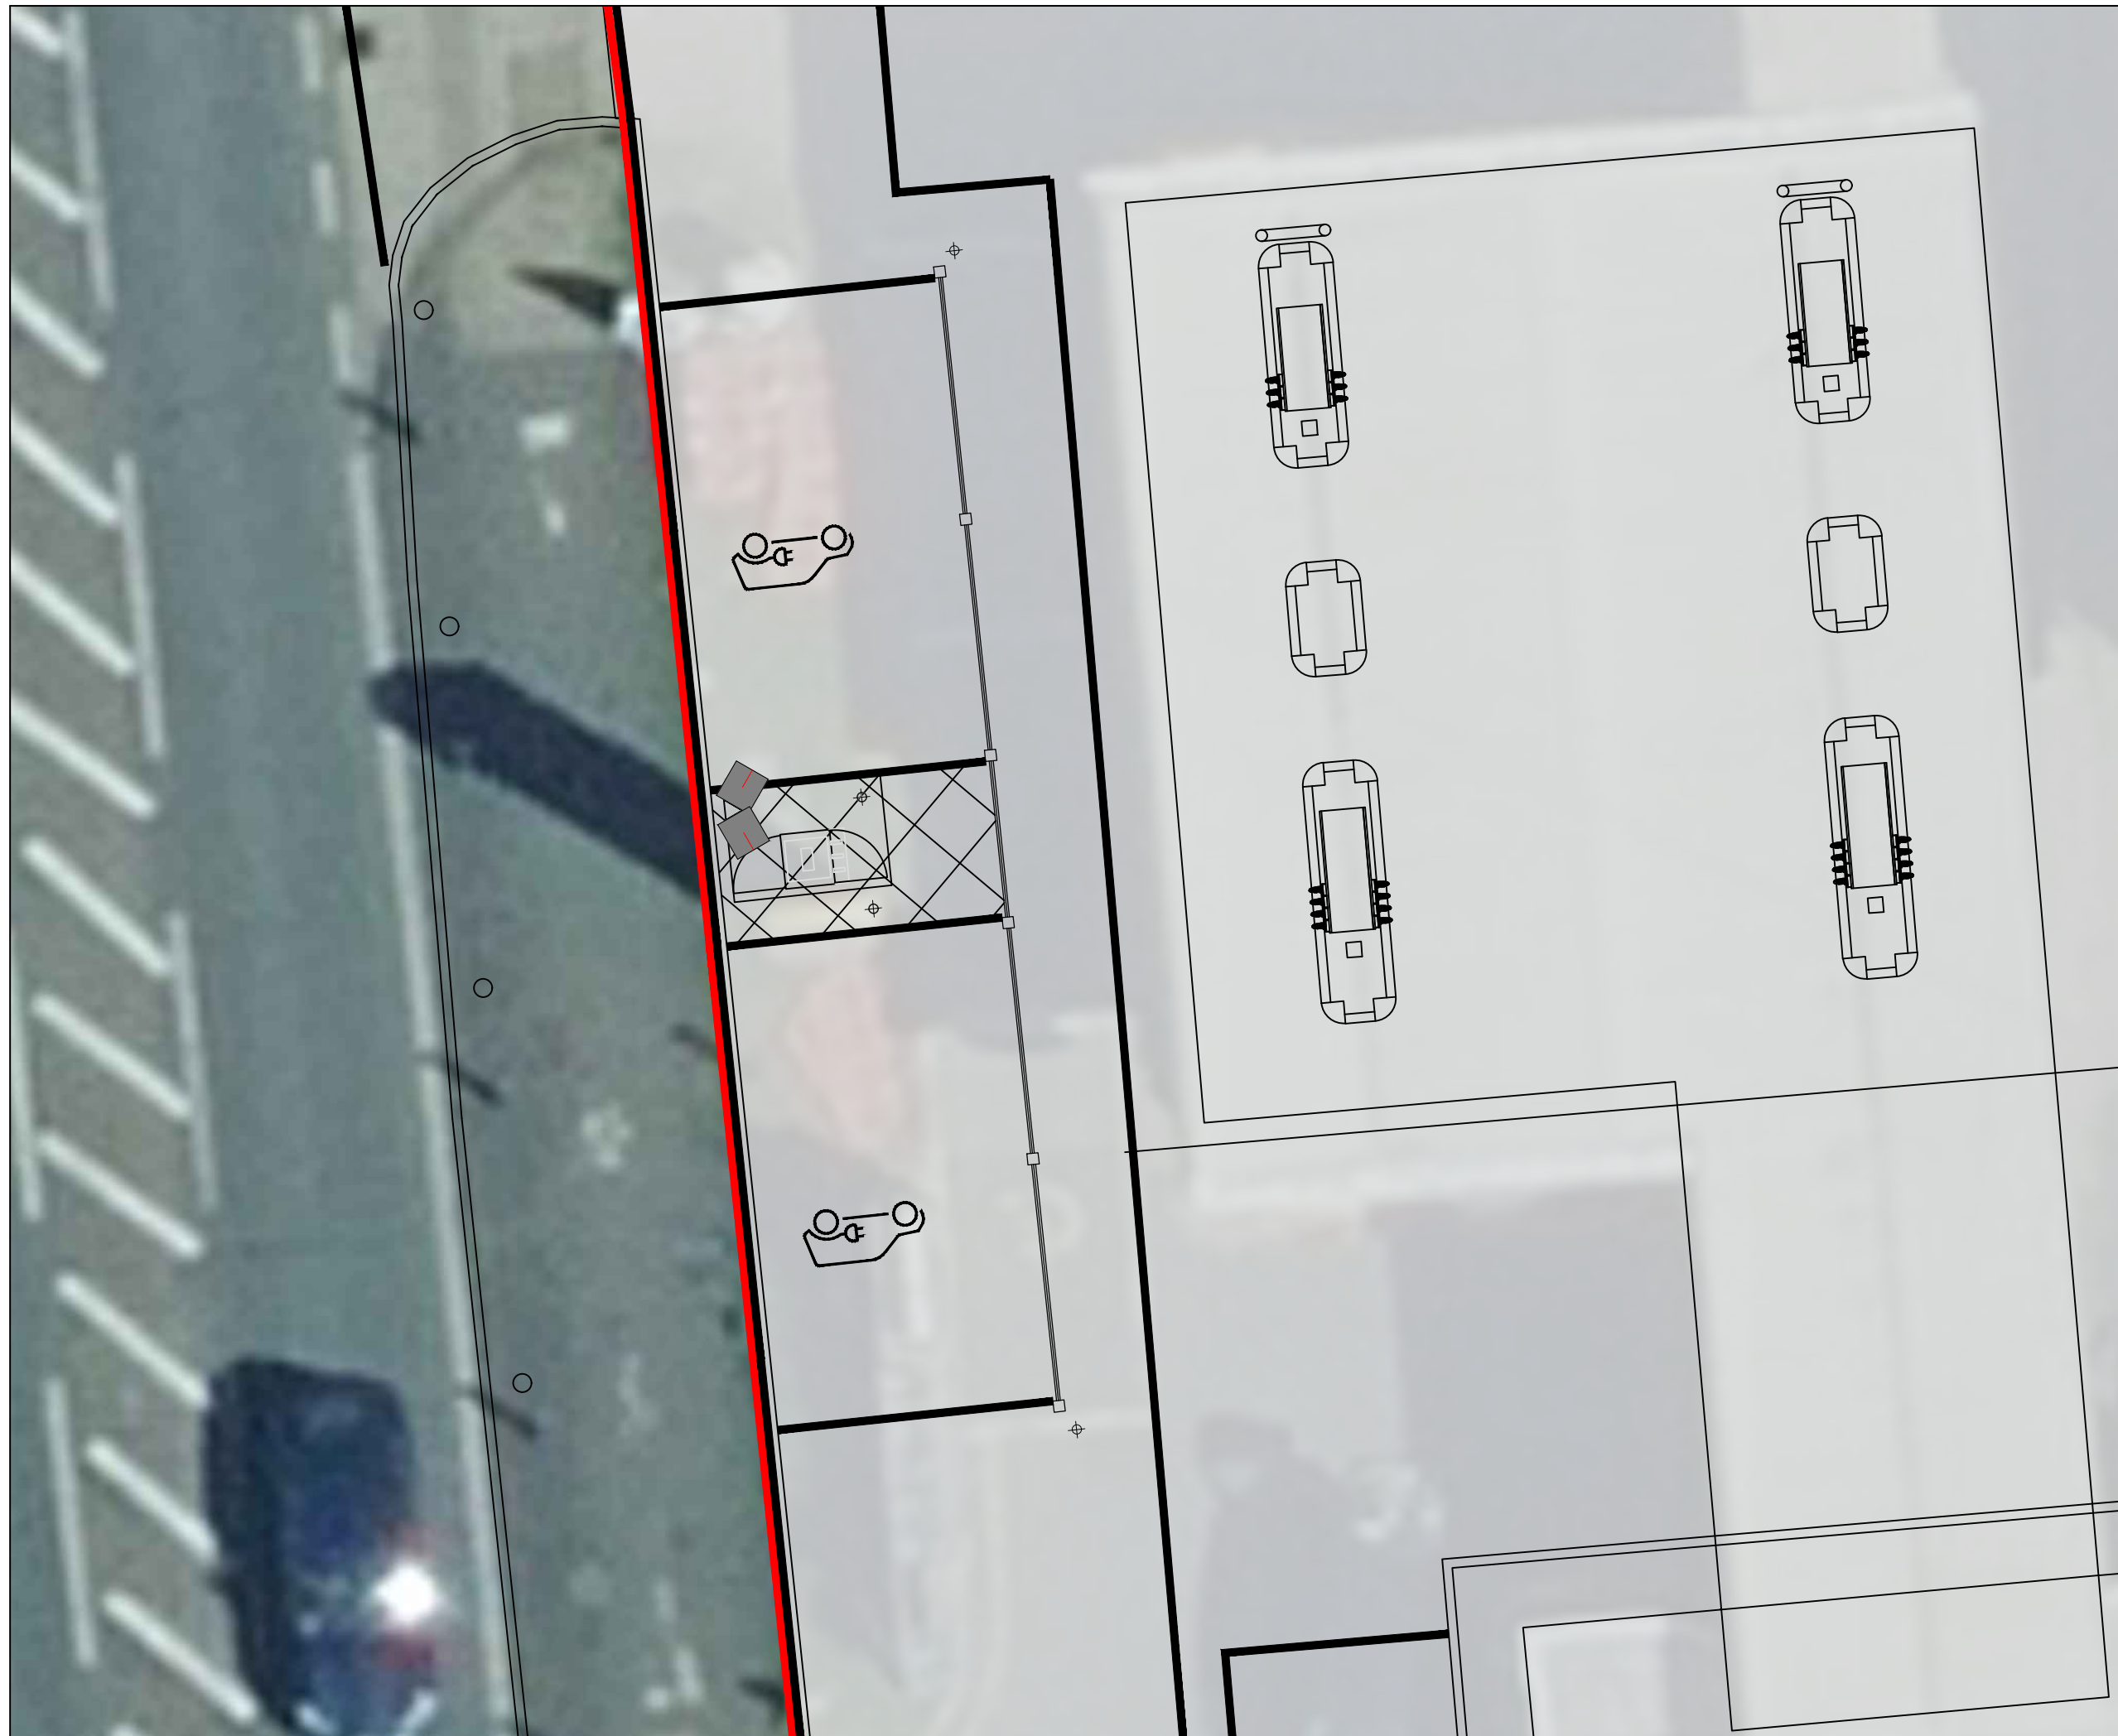

Notes:

1. This drawing is confidential and may not be reproduced, manufactured or exploited in whole or part without written consent.

2. Dimensions are not to be scaled from this drawing.

3. Official issues of this drawing are in paper or pdf format only. Dwg files are for reference only.

4. This drawing is for environmental planning purposes only and shall not be used for any other purpose.

LUMINAIRE SCHEDULE

■ BELL Skyline Virtus 50/75/100W 3000K LED
switched @50W Asy' + 360° visor @FGL +5m

Rev	Date	Details	Drawn
Project	Findon Service Station EVC		
Assessed Scheme of Lighting			
Strenger Ltd			
Date	Scale	Drawn	
DEC 25	NTS	DC	
Drawing No. SK-02			
Status	FOR ENV' PLANNING		
Checked	OC	Print	A3