


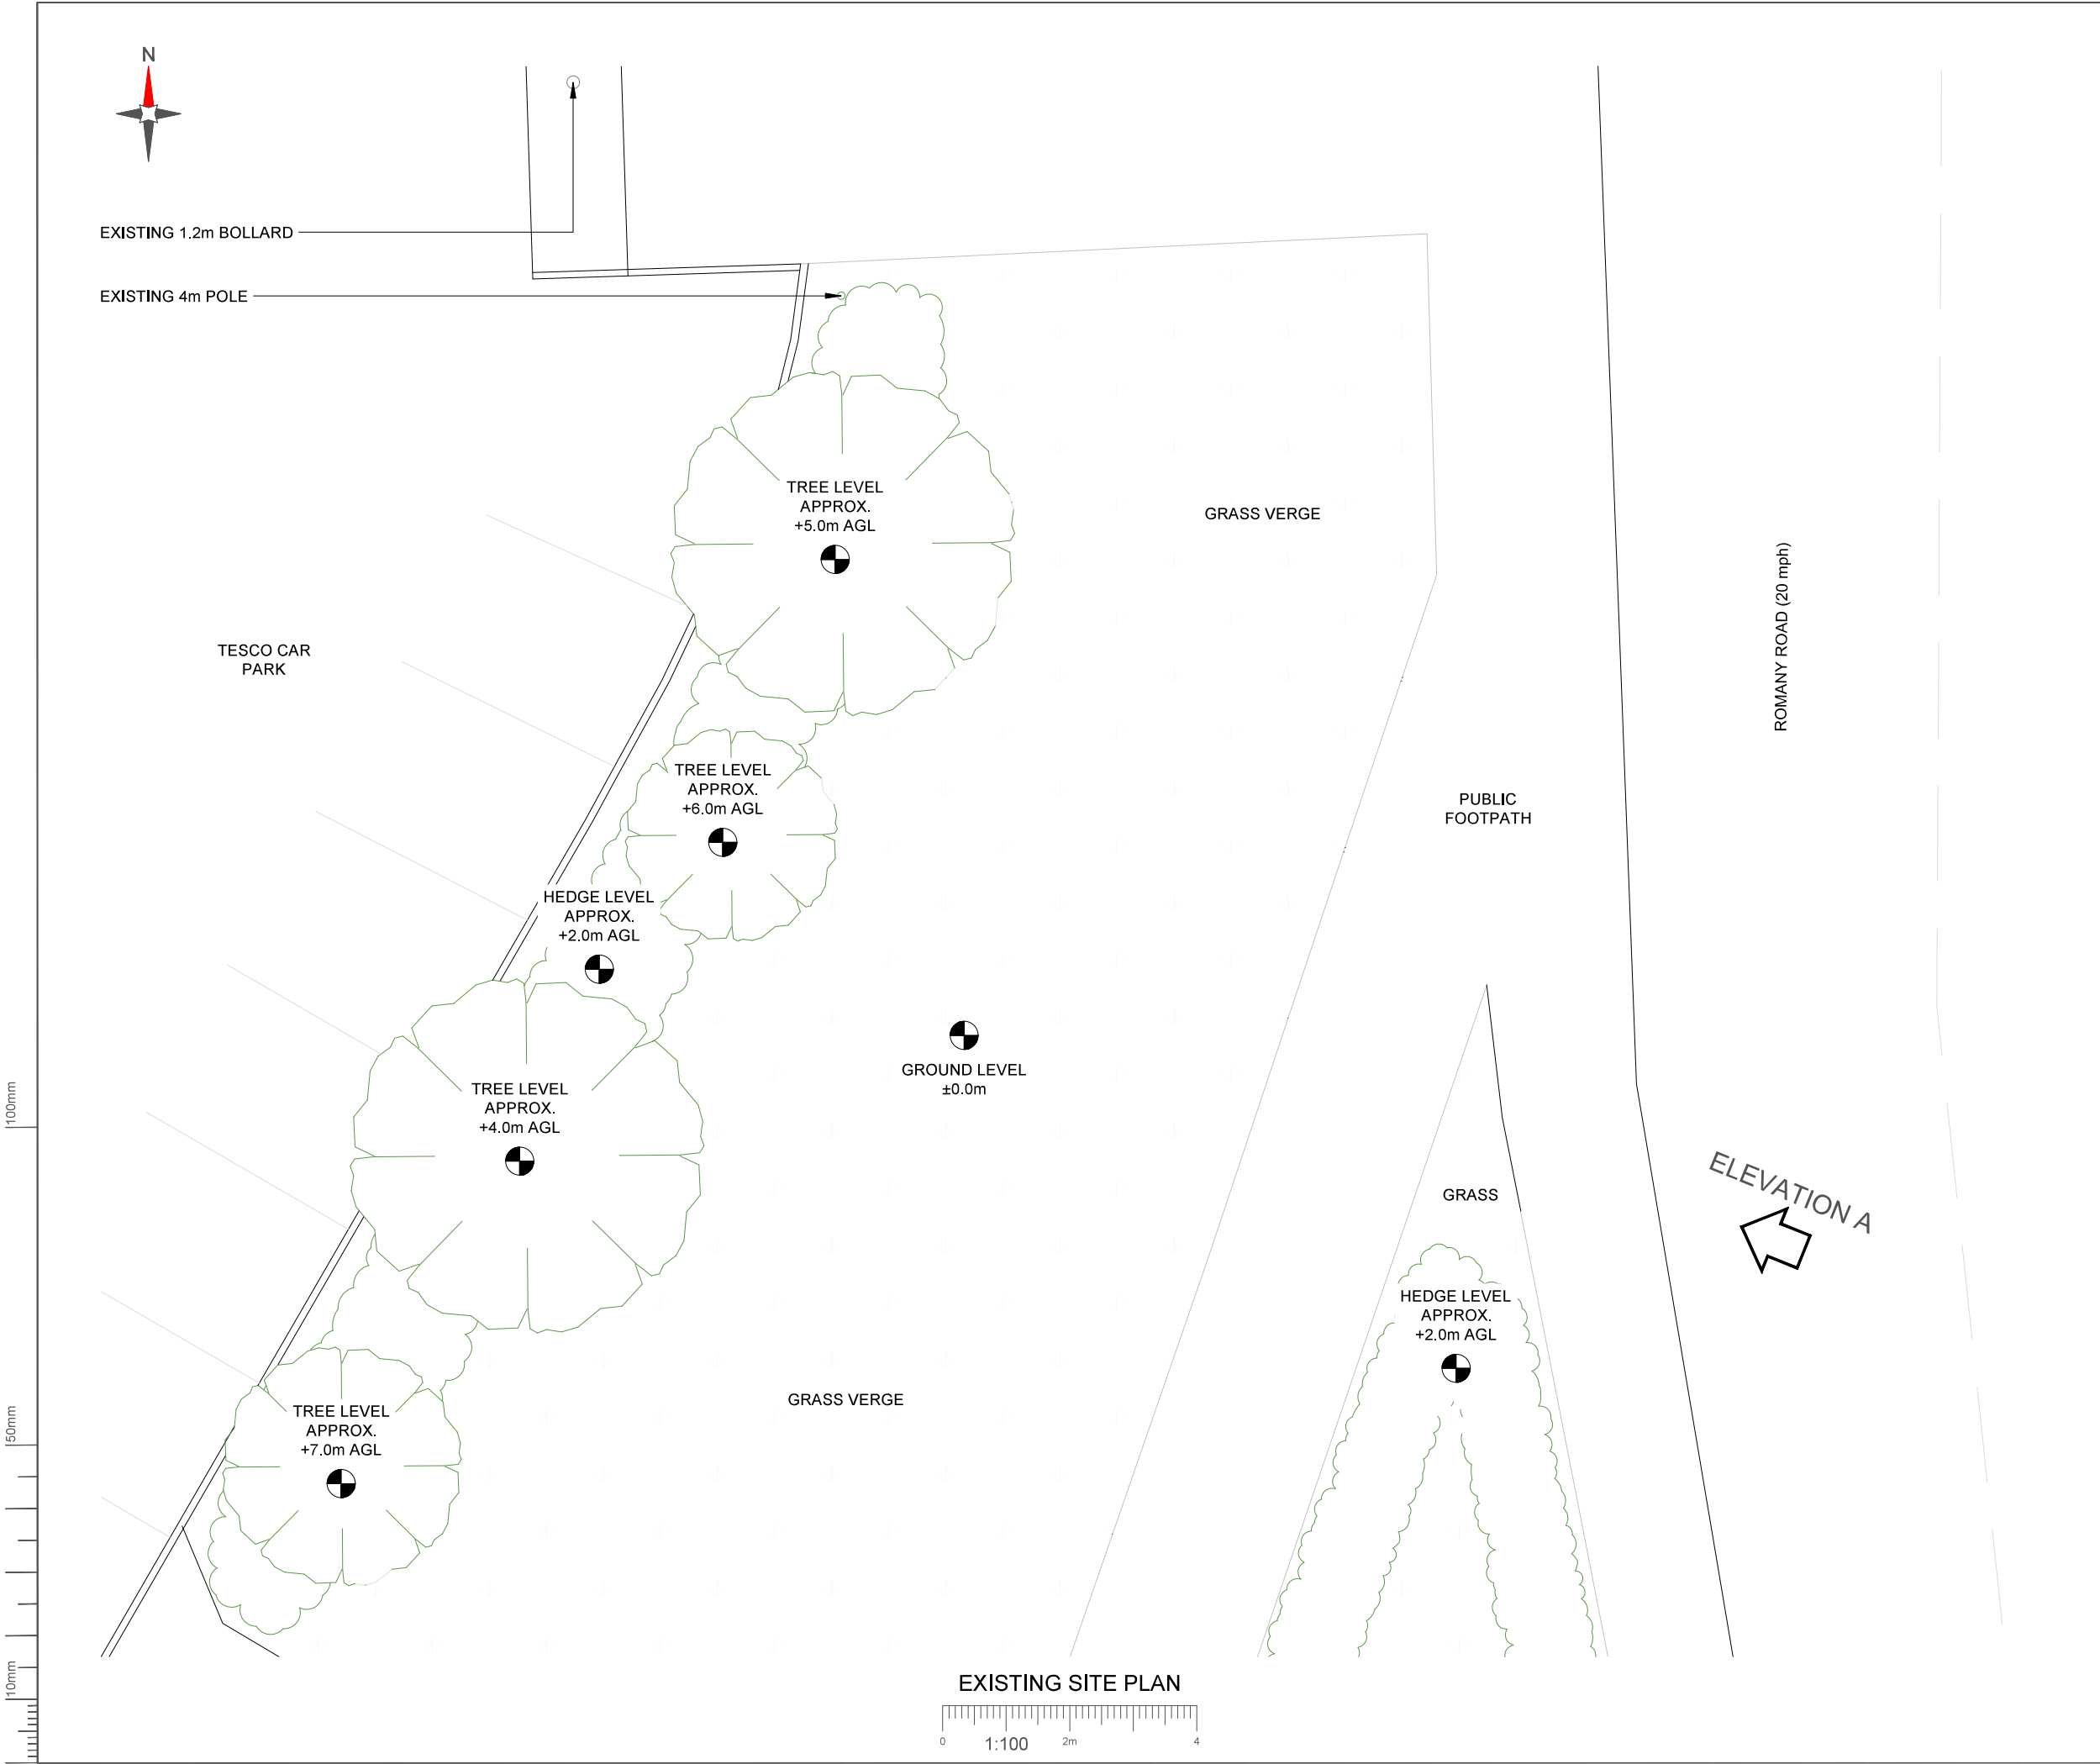

- NOTES:
- ALL DIMENSIONS IN MM UNLESS OTHERWISE NOTED.

Master:	Project:		Purpose of Issue:	Issue:
M002	MBNL NTQ		GA	B
Date:	02/10/2025	Revision / Upgrade Description:		
Drawn:	A.Bondos	Minor amend: EMF calculator amended to align with Sector B		
Checked:	S.Smith	ICNIRP option.		
Approved:	A.Bailey			
Master:	Project:		Purpose of Issue:	Issue:
M001	MBNL NTQ		GA	A
Date:	17/09/2025	Revision / Upgrade Description:		
Drawn:	A.Bondos	First Issue - Site nomination dated: 15/09/2025		
Checked:	S.Smith			
Approved:	A.Bailey			



Hutchison 3G UK Limited
Green Park, 450 Longwater Avenue
Reading, RG30 3UR
Tel: 01628 765 000
Fax: 01628 765 001

H3G Base Station Information Line
0845 6043000
Available 9am-5pm Monday to Friday



Everything Everywhere
One Braham Street
London
E1 6EE
Tel: 020 7356 5000



Mobile Broadband Network Limited
Sixth Floor, Thames Tower, Station Road, Reading, RG1 1LX

Design Consultant & Principal Contractor:



M GROUP TELECOM
WEST LODGE
STATION APPROACH
WEST BYFLEET
SURREY
KT14 6NG
TEL : 01932 623592

Site Name: TESCO DURREINGTON

Site ID: 1645236

Address: TESCO DURREINGTON,
NEW ROAD,
WORTHING,
WEST SUSSEX,
BN13 3FJ

Title: 100 EXISTING SITE PLAN

Project: NTQ

Purpose of Issue: GENERAL ARRANGEMENT

EE Cell ID:	MBNL Cell ID:	H3G Cell ID:
98365	WTG054	BN0914

File name: WTG054_98365_BN0914_MBNL_NTQ_GAD_B