


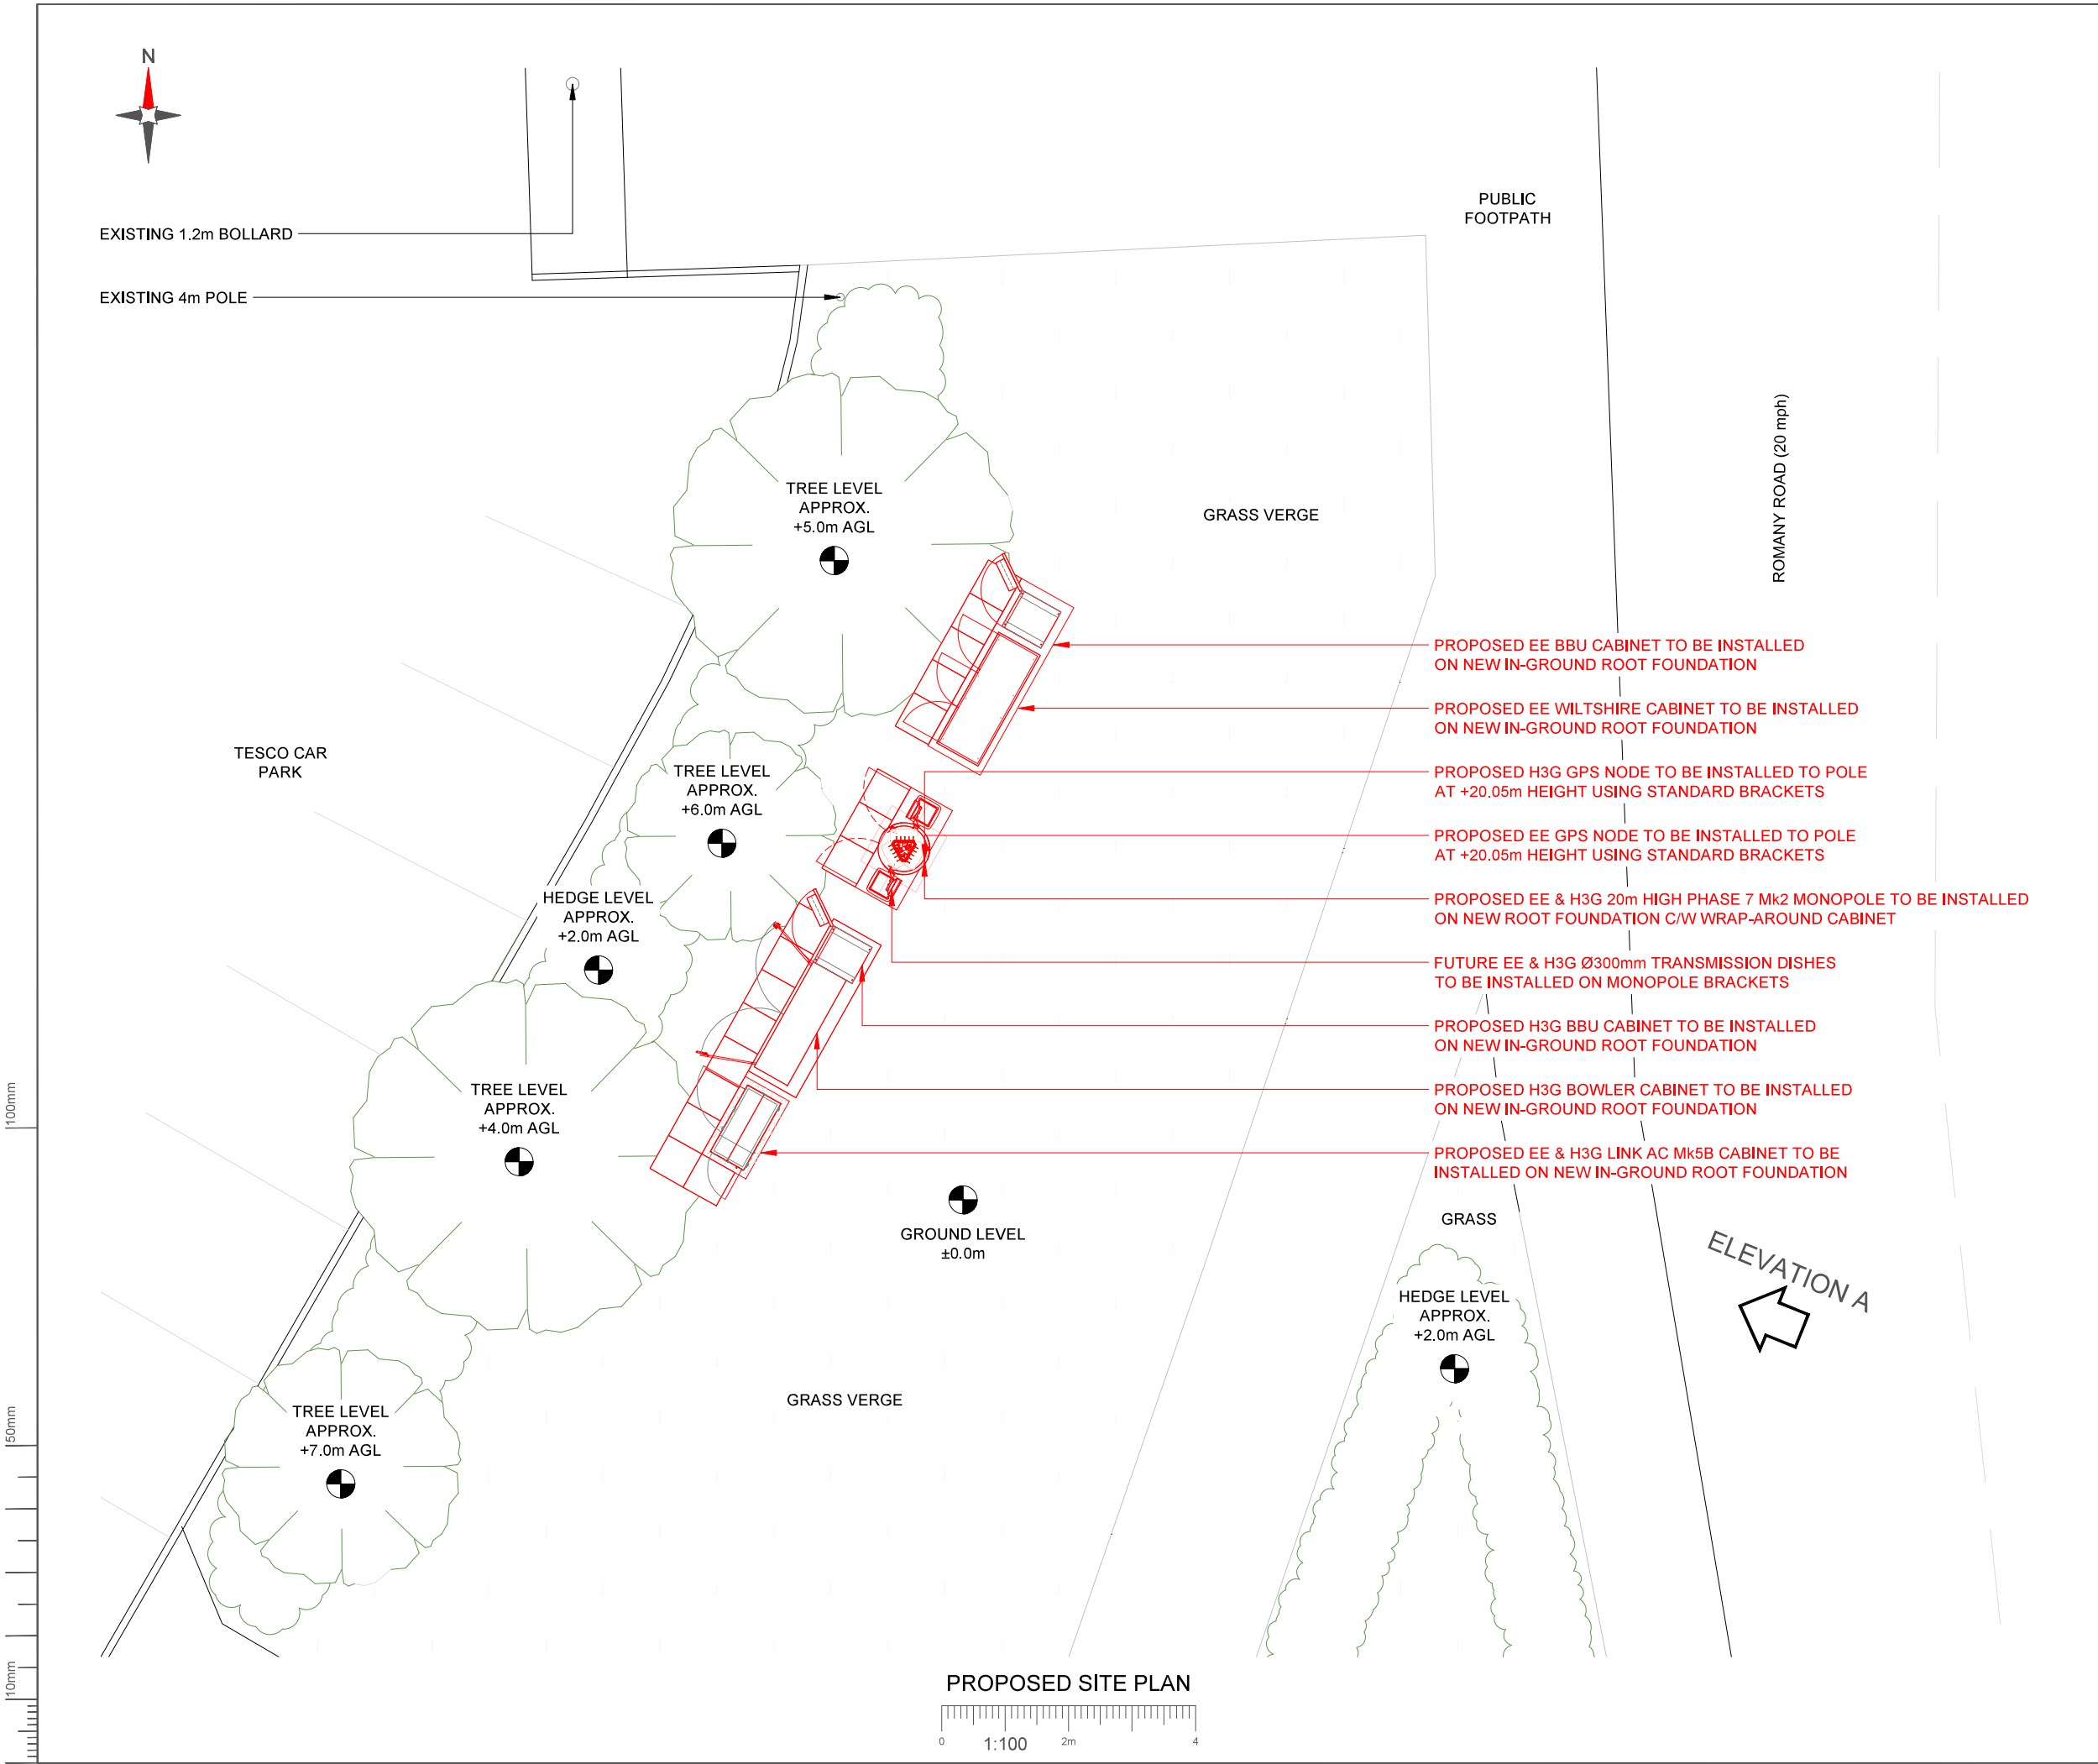

NOTES:
1. ALL DIMENSIONS IN MM UNLESS OTHERWISE NOTED.

Master:	M002	Project:	MBNL NTQ	Purpose of Issue:	GA	Issue:	B
Date:	02/10/2025	Revision / Upgrade Description:					
Drawn:	A.Bondos	Minor amend: EMF calculator amended to align with Sector B					
Checked:	S.Smith	ICNIRP option.					
Approved:	A.Bailey						

Master:	M001	Project:	MBNL NTQ	Purpose of Issue:	GA	Issue:	A
Date:	17/09/2025	Revision / Upgrade Description:					
Drawn:	A.Bondos	First Issue - Site nomination dated: 15/09/2025					
Checked:	S.Smith						
Approved:	A.Bailey						

Hutchison 3G UK Limited
Green Park, 450 Longwater Avenue
Reading, RG30 2UR
Tel: 01628 785 000
Fax: 01628 785 001

H3G Base Station Information line
0845 6043000
Available 8am-6pm Monday to Friday

Everything Everywhere
One Braham Street
London
E1 6EE

Tel: 020 7356 5000

Mobile Broadband Network Limited
Sixth Floor, Thames Tower, Station Road, Reading, RG1 1LX

Design Consultant & Principal Contractor:

M GROUP TELECOM
WEST LODGE
STATION APPROACH
WEST BYFLEET
SURREY
KT14 6NG

TEL : 01932 623592

Site Name:

TESCO DURREINGTON

Site ID:

1645236

Address:

TESCO DURREINGTON,
NEW ROAD,
WORTHING,
WEST SUSSEX,
BN13 3FJ

Title:

150 PROPOSED SITE PLAN

Project:

NTQ

Purpose of Issue:

GENERAL ARRANGEMENT

EE Cell ID:	MBNL Cell ID:	H3G Cell ID:
98365	WTG054	BN0914

File name:

WTG054_98365_BN0914_MBNL_NTQ_GAD_B