
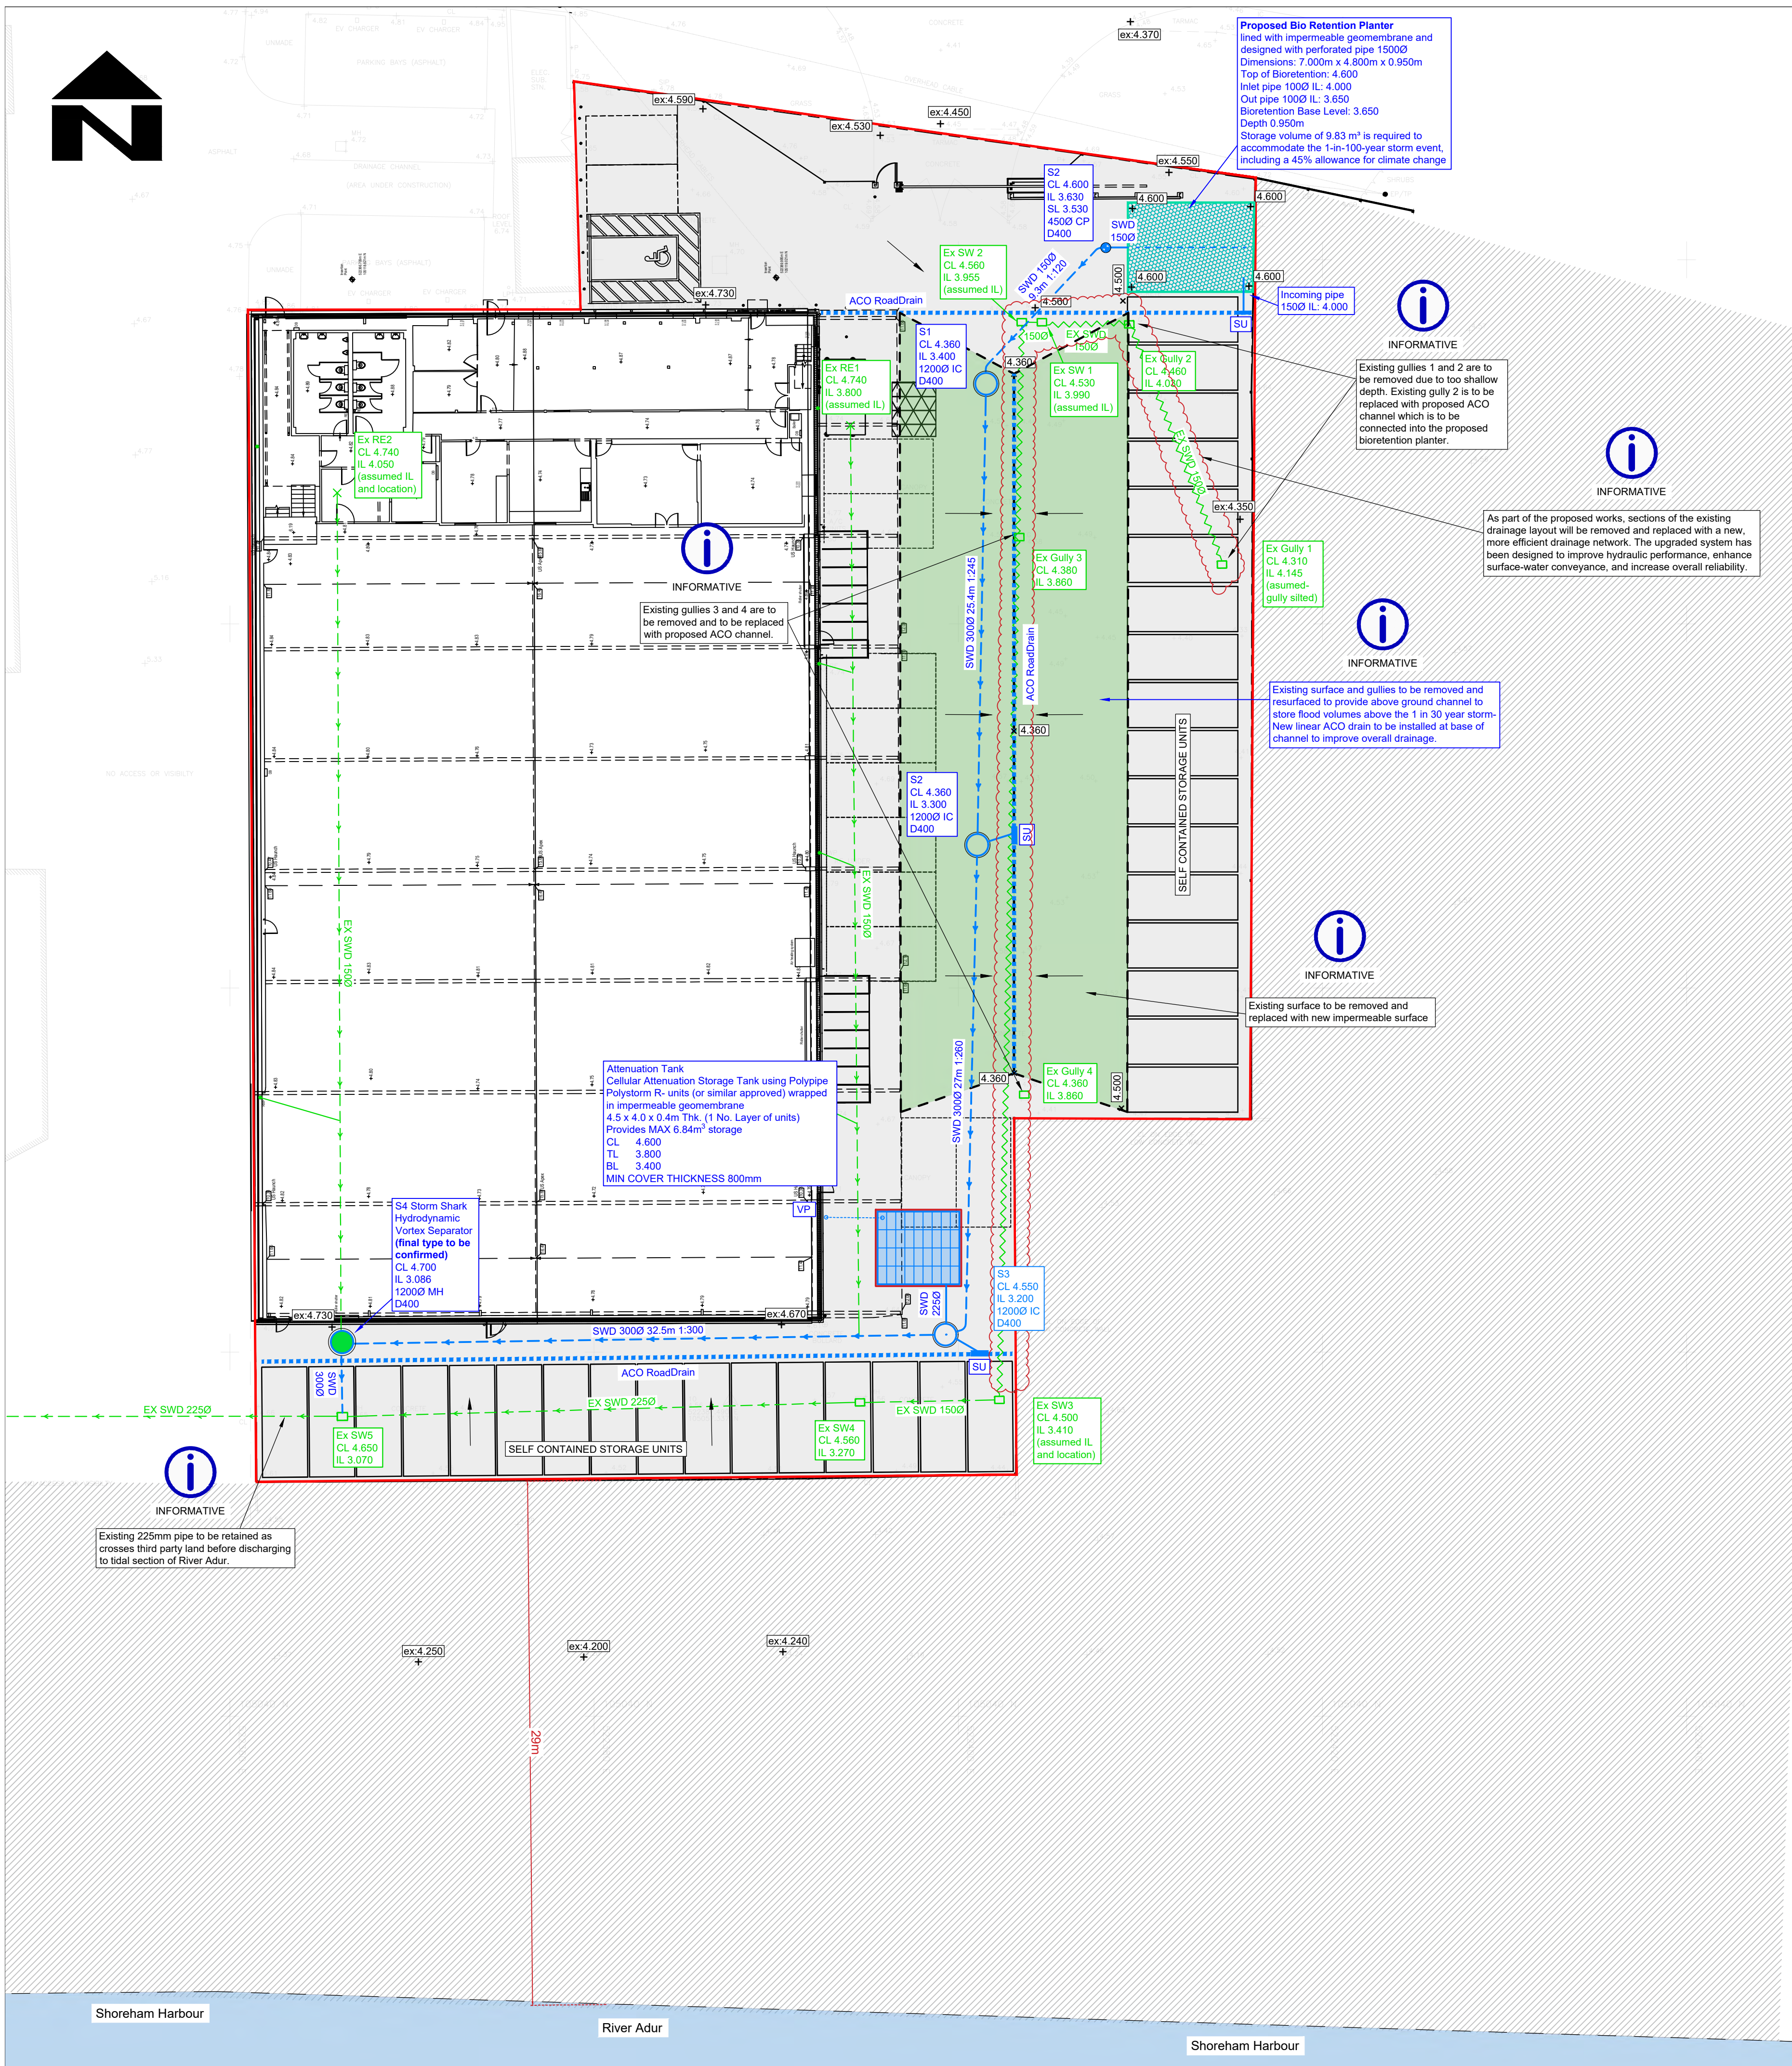


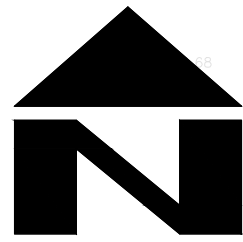

DRAINAGE LEGEND

EXISTING FEATURES

Existing surface water sewer/drain and manhole as taken from topographical survey information and provided from HPM 'Indicative Drainage Strategy Layout 29141-200'

PROPOSED FEATURES

SWD Surface Water Drainage
ACO ACO Drain channel
Storm water manhole (10500)
Proposed Hydrodynamic Vortex Separator 12000
Storm water catchpit chamber (4500)
Proposed Bioretention planter unit with perforated 1000 pipe
Proposed area of 'above-ground storage' graded to fall towards the central ACO channel.
Proposed surface level
Fall in surface
Pipe info - diameter, length, gradient, bedding type
1000 4.5m 1:100 Z BED

ABBREVIATIONS

MH - MANHOLE
IC - INSPECTION CHAMBER
AC - ACCESS CHAMBER
CP - CATCHPIT
BC - BRAKE CHAMBER
RE - RODDING EYE
IL - INVERT LEVEL
SL - SUMP LEVEL
RA - RESTRICTED ACCESS COVER
CL - COVER LEVEL
TL - TOP OF CELLULAR SA
BL - BASE OF CELLULAR SA
FL - FORMATION LEVEL

Site Boundary 0.364 ha
(as taken from S+SA Architects 'Proposed Site Plan' drawing no: 6951-SSA-XX-XX-DR-A-007 P3; dated: 22.07.25)

STANDARD DRAINAGE NOTES

- DO NOT SCALE FROM THIS DRAWING. REFER TO FIGURED DIMENSIONS ONLY. THE CONTRACTOR SHOULD CHECK ALL DIMENSIONS ON SITE.
- ALL DIMENSIONS IN MILLIMETRES AND ALL LEVELS ARE IN METERS UNLESS NOTED OTHERWISE.
- THIS DRAWING SHOULD BE READ IN CONJUNCTION WITH ALL OTHER RELEVANT ARCHITECT AND ENGINEERING DETAILS, DRAWINGS AND SPECIFICATIONS.
- ANY DISCREPANCIES SHOULD BE REPORTED TO THE ARCHITECT AND/OR ENGINEER IMMEDIATELY, SO THAT CLARIFICATION CAN BE SOUGHT PRIOR TO THE COMMENCEMENT OF WORK.
- BEFORE COMMENCING CONSTRUCTION THE CONTRACTOR MUST CHECK THE INVERT LEVELS OF EXISTING SEWERS TO WHICH CONNECTIONS ARE MADE. IN ADDITION THE CONTRACTOR MUST LOCATE AND DETERMINE INVERT LEVELS OF THE EXISTING SPURS TO WHICH CONNECTIONS ARE PROPOSED. ANY DISCREPANCIES ARE TO BE NOTIFIED TO THE ENGINEER IMMEDIATELY, PRIOR TO CONSTRUCTION.
- ALL DRAINAGE WORKS SHOULD COMMENCE AT THE PROPOSED DOWNSTREAM CONNECTION POINT. THE WORKS CONTINUING UPSTREAM FOLLOWING CONFIRMATION OF THE TIE-IN INVERT LEVELS TO THE ENGINEER. CONNECTIONS TO MANHOLES OR LARGER SIZED PIPES ETC. SHOULD BE SOFFIT TO SOFFIT UNLESS OTHERWISE INSTRUCTED BY THE ENGINEER, IF THIS IS NOT POSSIBLE INFORM THE ENGINEER IMMEDIATELY.
- COVER LEVELS SHOWN ARE APPROXIMATE. COVERS AND FRAMES SHALL BE SET TO FINISHED GROUND LEVELS AND FALLS.
- ALL UN-REFERENCED PIPES ARE TO BE 100mm DIA.
- ALL PIPES TO BE ADOPTED, OR CONNECTING TO ADOPTED SEWERS, TO BE VITRIFIED CLAY TO BS EN 295 AND BS65 (SWS ONLY), OR CONCRETE PIPES TO BE EN 1916 AND BS5911-PART 1.
- ROAD GULLY OUTLET PIPES ARE TO BE 150mm DIA. WITH CONCRETE SURROUND AND FLEXIBLE JOINTS. ALL GULLIES SHALL BE FITTED WITH GRADE D400 GRATINGS AND FRAMES TO BS EN124, UNLESS OTHERWISE STATED.
- ALL ADOPTABLE SEWERS SHALL BE CONSTRUCTED TO THE STANDARDS AND SPECIFICATION LAID DOWN IN 'SEWERS FOR ADOPTION' 6th EDITION, WITH A VIEW TO ADOPTION UPON COMPLETION OF WORKS.
- ALL PRIVATE DRAINAGE TO BE IN ACCORDANCE WITH THE BUILDING REGULATIONS APPROVED DOCUMENT PART-H, AND TO THE SATISFACTION OF THE BUILDING CONTROL INSPECTOR.
- THE CONTRACTOR IS TO KEEP A RECORD OF ANY VARIATIONS MADE ON SITE, INCLUDING THE RELOCATION OF SEWERS OR DRAINS, SO THAT AN AS CONSTRUCTED DRAWINGS CAN BE PREPARED UPON COMPLETION OF THE PROJECT.
- STUB CONNECTIONS TO ADOPTABLE MANHOLES SHALL BE MADE FROM VITRIFIED CLAY AND CONSIST OF TWO ROCKER PIPES LAID AT THE SAME GRADIENT AS THE UP OR DOWNSTREAM PIPE.
- IF ANY SUB SOIL DRAINAGE SYSTEMS ARE UNCOVERED DURING THE WORKS CONTACT THE ENGINEER FOR INSTRUCTIONS. SUB SOIL DRAINS ARE TO BE DIVERTED AROUND NEW WORKS AND CONNECTED INTO THE SURFACE WATER.
- NO PRIVATE AREAS ARE TO DRAIN ONTO ADOPTABLE AREAS AND VICE VERSA.
- ALL EXISTING MANHOLE COVER'S, GULLIES, ETC. ARE TO BE RAISED/LOWERED TO SUIT NEW LEVELS.
- IT IS THE RESPONSIBILITY OF THE CONTRACTOR TO CONFIRM THE LOCATION AND DEPTH OF ALL EXISTING SERVICES AND UTILITIES THAT MAY BE PRESENT.
- UPON COMPLETION BUT PRIOR TO HANDOVER, CONTRACTOR TO CARRY OUT FULL CCTV SURVEY OF DRAINAGE SYSTEM WHICH IS TO BE REVIEWED BY ENGINEER TO ENSURE SATISFACTORY INSTALLATION.
- PROPRIETARY PRODUCTS TO BE INSTALLED IN FULL ACCORDANCE WITH MANUFACTURER'S GUIDANCE.
- MANHOLE AND CHAMBER COVER GRADES:
 - 'A15' IN ALL LANDSCAPED AREAS AND ON FOOTPATHS
 - 'B125' IN ALL DRIVEWAYS
 - 'C250' IN PRIVATE PARKING AREAS
 - 'D400' IN CARRIAGEWAY/ACCESS ROAD

Prefixed to drawing numbers shall signify the following:-

PL = PLANNING	Shall not be used for contract or construction purposes
P = PRELIMINARY	Shall not be used for contract or construction purposes
T = TENDER	Shall not be used for construction purposes
C = CONSTRUCTION	These are the only drawings that shall be used for construction purposes
R = RECORD	Record of actual completed work

Site Specific Notes

- Surface water network designed to the critical 1 in 100 year storm event plus an allowance of 45% for the predicted effects of climate change.
- Hydraulic calculations based on FEH22 rainfall data.
- As the impermeable area of the development remains unchanged from the existing, and given that the site lies approximately 30 m north of the River Adur, the proposed surface water strategy focuses on improving the existing system. The design reduces loading on the existing drainage network by upgrading drainage features, replacing existing gullies with more efficient linear ACO channels, and enhancing overall flow conveyance.
- Proposed Bioretention Planter and Hydrodynamic Vortex Separator included to provide treatment of surface water runoff.
- Offline attenuation tank provided to prevent flooding of the S3 manhole area.

DESIGN SUBJECT TO THE APPROVAL OF:
PLANNING AUTHORITY
BUILDING CONTROL

DESIGN SUBJECT TO THE CONFIRMATION OF:
EXTERNAL LEVELS DESIGN
LOCATION AND DEPTH OF EXISTING UTILITIES

PRELIMINARY

P-	05.12.25	PRELIMINARY ISSUE	MR	CS	CS
REV	DATE	DESCRIPTION	BY	CHK	APP
CLIENT	OAKFIELD CONSTRUCTION LTD				
ARCHITECT	S+SA ARCHITECTS				
JOB TITLE	NEW WHARF, SHOREHAM BY SEA BN43 6RN				
DRAWING TITLE	PROPOSED DRAINAGE PLAN				
DRAWN	MR	ENGINEER	CS	CHECKED	CS
DATE	DECEMBER 2025	SCALE @ A1	1:200		
JOB No.	C3919	STATUS	P	DRAWING No.	101
REV.	P-				