


- Services Key**
- SAT - Satellite television aerial point
  - CAT5 - data point
  - Denotes pull cord
  - Denotes light switch (2 way)
  - Denotes light switch (timer)
  - Denotes telephone
  - Denotes television aerial points
  - Denotes double socket
  - Denotes double socket (floor level)
  - Denotes cooker point
  - Denotes spur
  - Denotes external water tap
  - Denotes radiator
  - Denotes PIR detector
  - Denotes extractor fan
  - Denotes smoke detector
  - Denotes heat detector
  - Denotes meter
  - Denotes wall light
  - Denotes ceiling rose
  - Denotes spotlight
  - Denotes fluorescent tube

**Notes:**  
Final number of sockets, lights, radiators, positions etc to be agreed with the Client.  
Contractor to assess existing electrical system and meter/distribution board and advise of any additional work required due to new works.  
Structural Engineer to confirm all beams structure, layouts and sizes etc

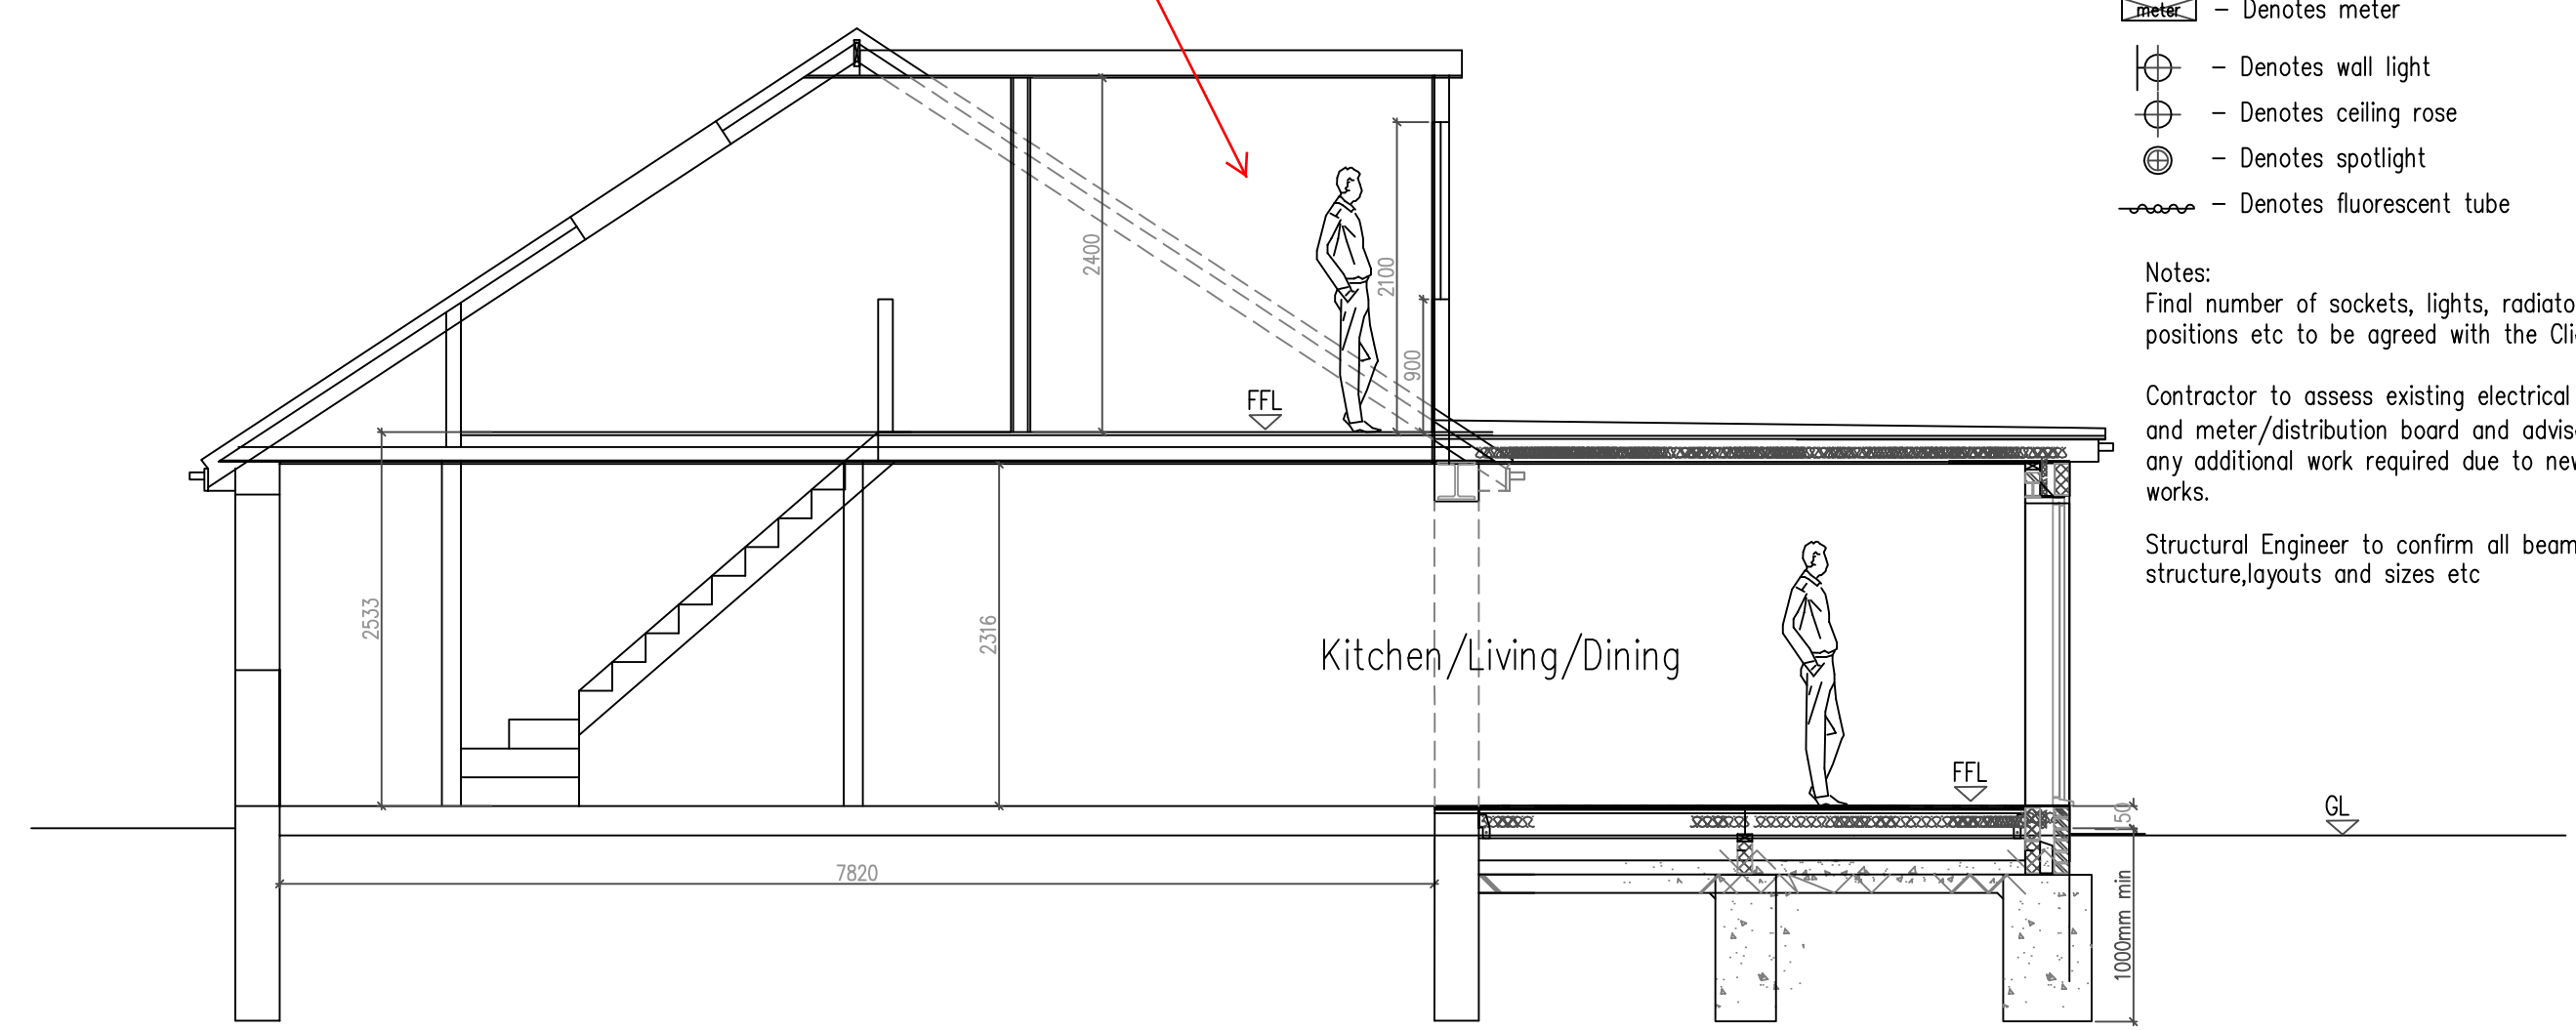

**12 SECTION A-A**  
1:50 Scale Bar

**NOTE:**


FW drain to be located/exposed, pipe diameter/depth of drain to be Flow direction /type of drain TBC by Building control  
All to be as Southern Water requirements and Approval

Protect FW pipe through new extension with 100x65mm concrete plank lintels  
For added FW drain protection - slab to be reinforced with A142 light mesh with 50mm cover  
If require depending on condition- replace FW pipe with new

No foundations are permitted within 500mm of the sewer without Southern Water's approval.  
Foundations are to be taken 150mm below invert level.  
Bridge over sewer with Supreme Concrete 100x140dp PC lintels spanning between new foundations and the existing external wall.  
Depth of sewer is to be confirmed before commencing works.

Structural Engineer to confirm all beam layouts and sizes

DO NOT SCALE FROM THIS DRAWING EXCEPT FOR PLANNING AS PHOTOCOPIES WILL BE SUBJECT TO DISTORTION  
DRAWINGS TO BE READ IN CONJUNCTION WITH ALL OTHER ARCHITECT'S & STRUCTURAL ENGINEER'S CONTRACT DRAWINGS & SPECIFICATIONS.  
ANY DISCREPANCIES MUST BE BROUGHT TO THE ATTENTION OF THE ARCHITECT IMMEDIATELY.  
THE CONTRACTOR MUST VERIFY ALL DIMENSIONS BY SITE MEASUREMENT BEFORE ORDERING MATERIALS OR MANUFACTURING COMPONENTS.  
SUBSTITUTE MATERIALS & PRODUCTS TO THOSE NAMED WILL BE ACCEPTABLE IF PROVEN TO BE OF EQUAL OR HIGHER PERFORMANCE AND NOT IN CONFLICT WITH OTHER ELEMENTS.  
FOUNDATIONS/FLOOR CONSTRUCTION DESIGNED BY STRUCTURAL ENGINEER TO SUIT LOCAL SOIL CONDITIONS. ALL TO BE APPROVED BY BUILDING CONTROL.

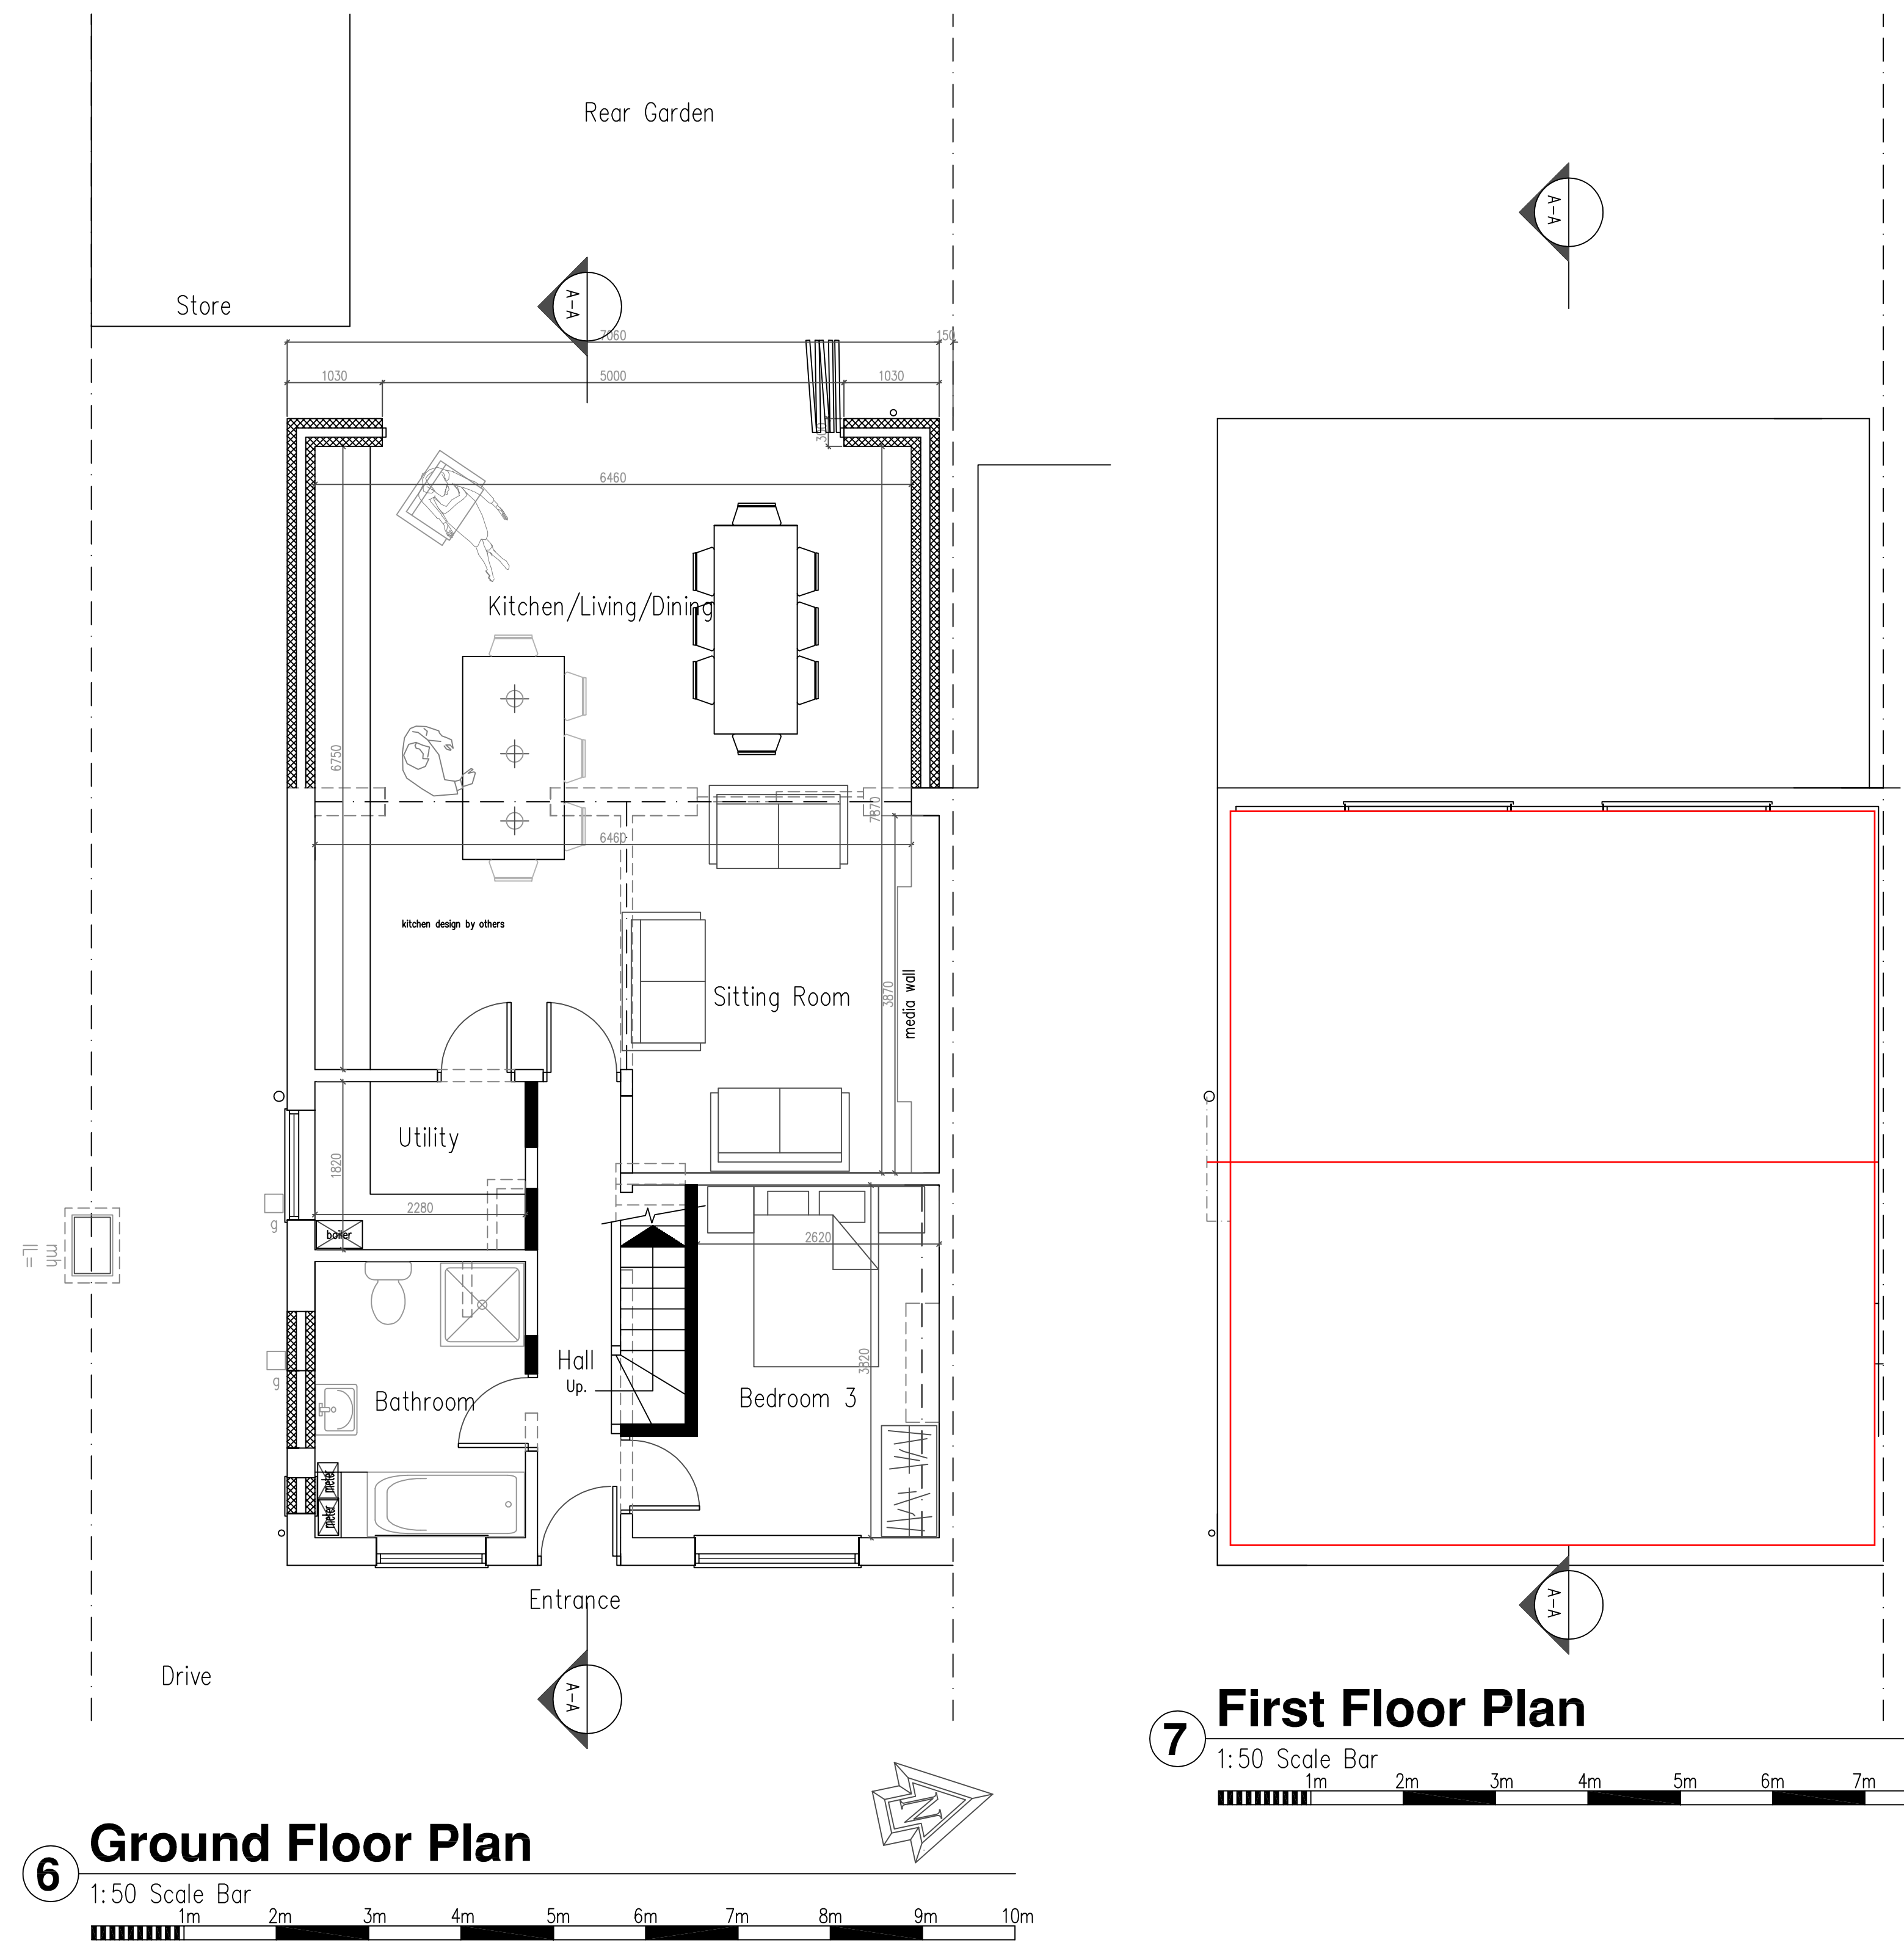

**7 First Floor Plan**  
1:50 Scale Bar

Project:  
Proposed, Rear Extension and Internal Alterations At:  
69 Crown Road  
Shoreham By Sea  
West Sussex  
BN43 6GD

Drawing title:  
Plans & Elevations As Proposed

Client:  
Sam Neville

© Copyright of:  
Architectural & Planning Services  
7 Erringham Rd  
Shoreham By Sea  
West Sussex  
BN43 5NQ  
**BJW**  
01273 441009  
07856899101  
e-mail: benw@bjwarchitectural.co.uk  
website: bjwarchitectural.co.uk

Scale: 1:50 1:100 Paper size A1

Date: 3.8.2026 Drawn: BJW

Drg. No. 02 Rev'n A

Note: All dimensions to be checked on site.