

Services Key

- SAT – Satellite television aerial point
- CATS – data point
- Denotes pull cord
- 2 – Denotes light switch (2 way)
- 1 – Denotes light switch (timer)
- ⌵ – Denotes telephone
- Denotes television aerial points
- Denotes double socket
- Denotes double socket (floor level)
- Δ – Denotes cooker point
- – Denotes spur
- Denotes external water tap

- Denotes radiator
- Denotes PR detector
- Denotes extractor fan
- Denotes smoke detector
- Denotes heat detector
- Denotes meter
- Denotes wall light
- Denotes ceiling rose
- Denotes spotlight
- Denotes fluorescent tube

Notes:
Final number of sockets, lights, radiators, positions etc to be agreed with the Client.
Contractor to assess existing electrical system and meter/distribution board and advise of any additional work required due to new works.

Structural Engineer to confirm all beam layouts and sizes

DO NOT SCALE FROM THIS DRAWING EXCEPT FOR PLANNING AS PHOTOGRAPHS WILL BE SUBJECT TO DISTORTION. DRAWINGS TO BE READ IN CONJUNCTION WITH ALL OTHER ARCHITECT'S & STRUCTURAL ENGINEER'S CONTRACT DRAWINGS & SPECIFICATIONS. ANY DISCREPANCIES MUST BE BROUGHT TO THE ATTENTION OF THE ARCHITECT IMMEDIATELY. THE CONTRACTOR MUST CHECK ALL DIMENSIONS BY SITE MEASUREMENTS BEFORE ORDERING MATERIALS OR SUBSTITUTE MATERIALS & PRODUCTS TO THOSE NAMED WILL BE ACCEPTABLE IF PROVEN TO BE OF EQUAL OR HIGHER PERFORMANCE AND NOT IN CONFLICT WITH OTHER ELEMENTS. FOUNDATIONS/FLOOR CONSTRUCTION DESIGNED BY STRUCTURAL ENGINEER TO SUIT LOCAL SOIL CONDITIONS PROXIMITY TO TREES ETC. ALL TO BE APPROVED BY BUILDING CONTROL.

Project:

Proposed
Side Extension
and Internal Alterations At:
37 Rectory Road
Lancing
West Sussex

Drawing title:

Plans & Elevations As Proposed

Client:

Date Marshall

© Copyright of:

Architectural & Planning Services
7 Errington Rd
Storrham By Sea
West Sussex
BN45 5NQ


BJW
01273 441009
email: bjam@bjwarchitectural.co.uk
website: bjwarchitectural.co.uk

Scale: 1:50 1:100 Paper size: A1

Date: 16.9.2025 Drawn: BJW

Dwg. No. 02 Rev'n 6

Notes: All dimensions to be checked on site.

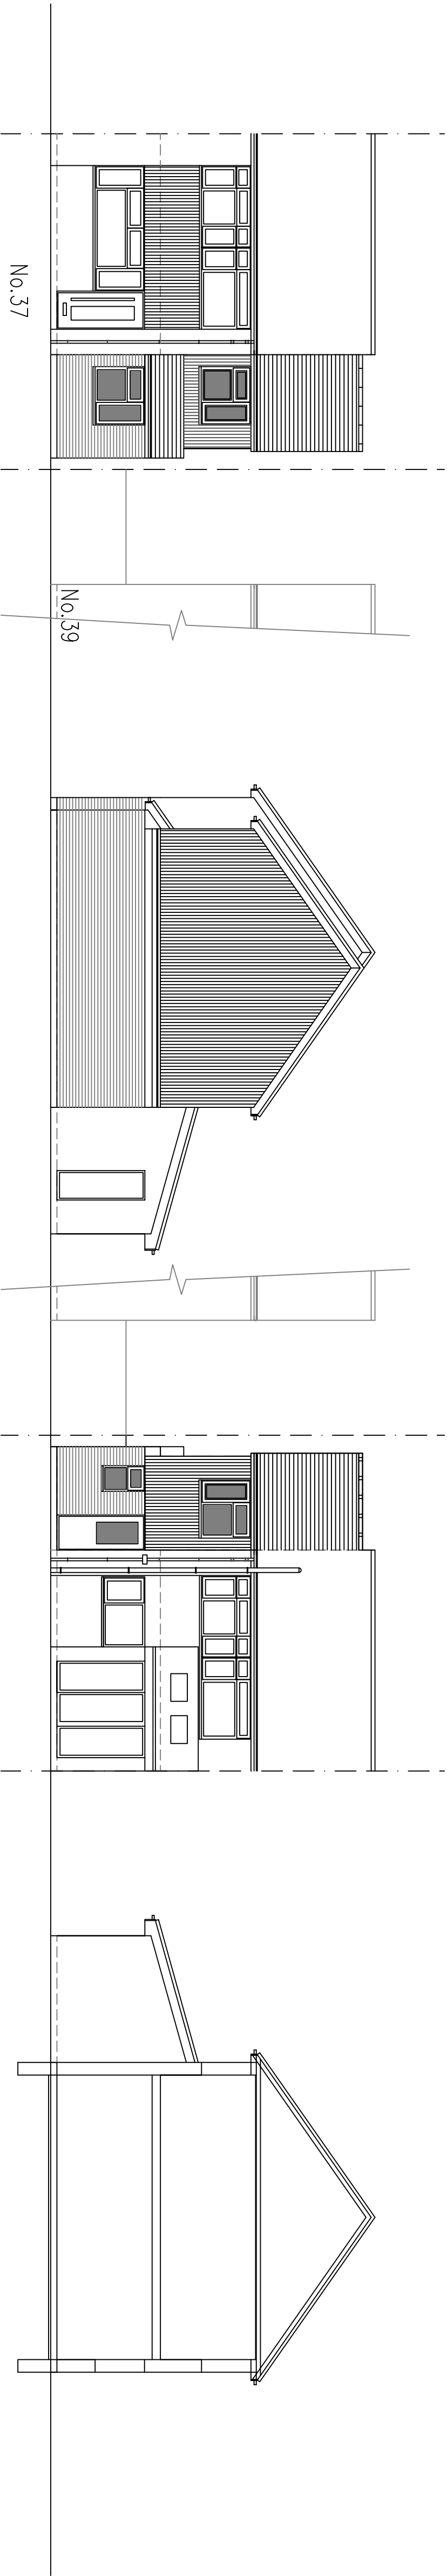

7 East Facing Front Elevation

1m 2m 3m 4m 5m 6m 7m 8m 9m 10m
1:100 Scale Bar

8 North Facing Side Elevation


1m 2m 3m 4m 5m 6m 7m 8m 9m 10m
1:100 Scale Bar

9 West Facing Rear Elevation

1m 2m 3m 4m 5m 6m 7m 8m 9m 10m
1:100 Scale Bar

10 South Facing Side Elevation


1m 2m 3m 4m 5m 6m 7m 8m 9m 10m
1:100 Scale Bar

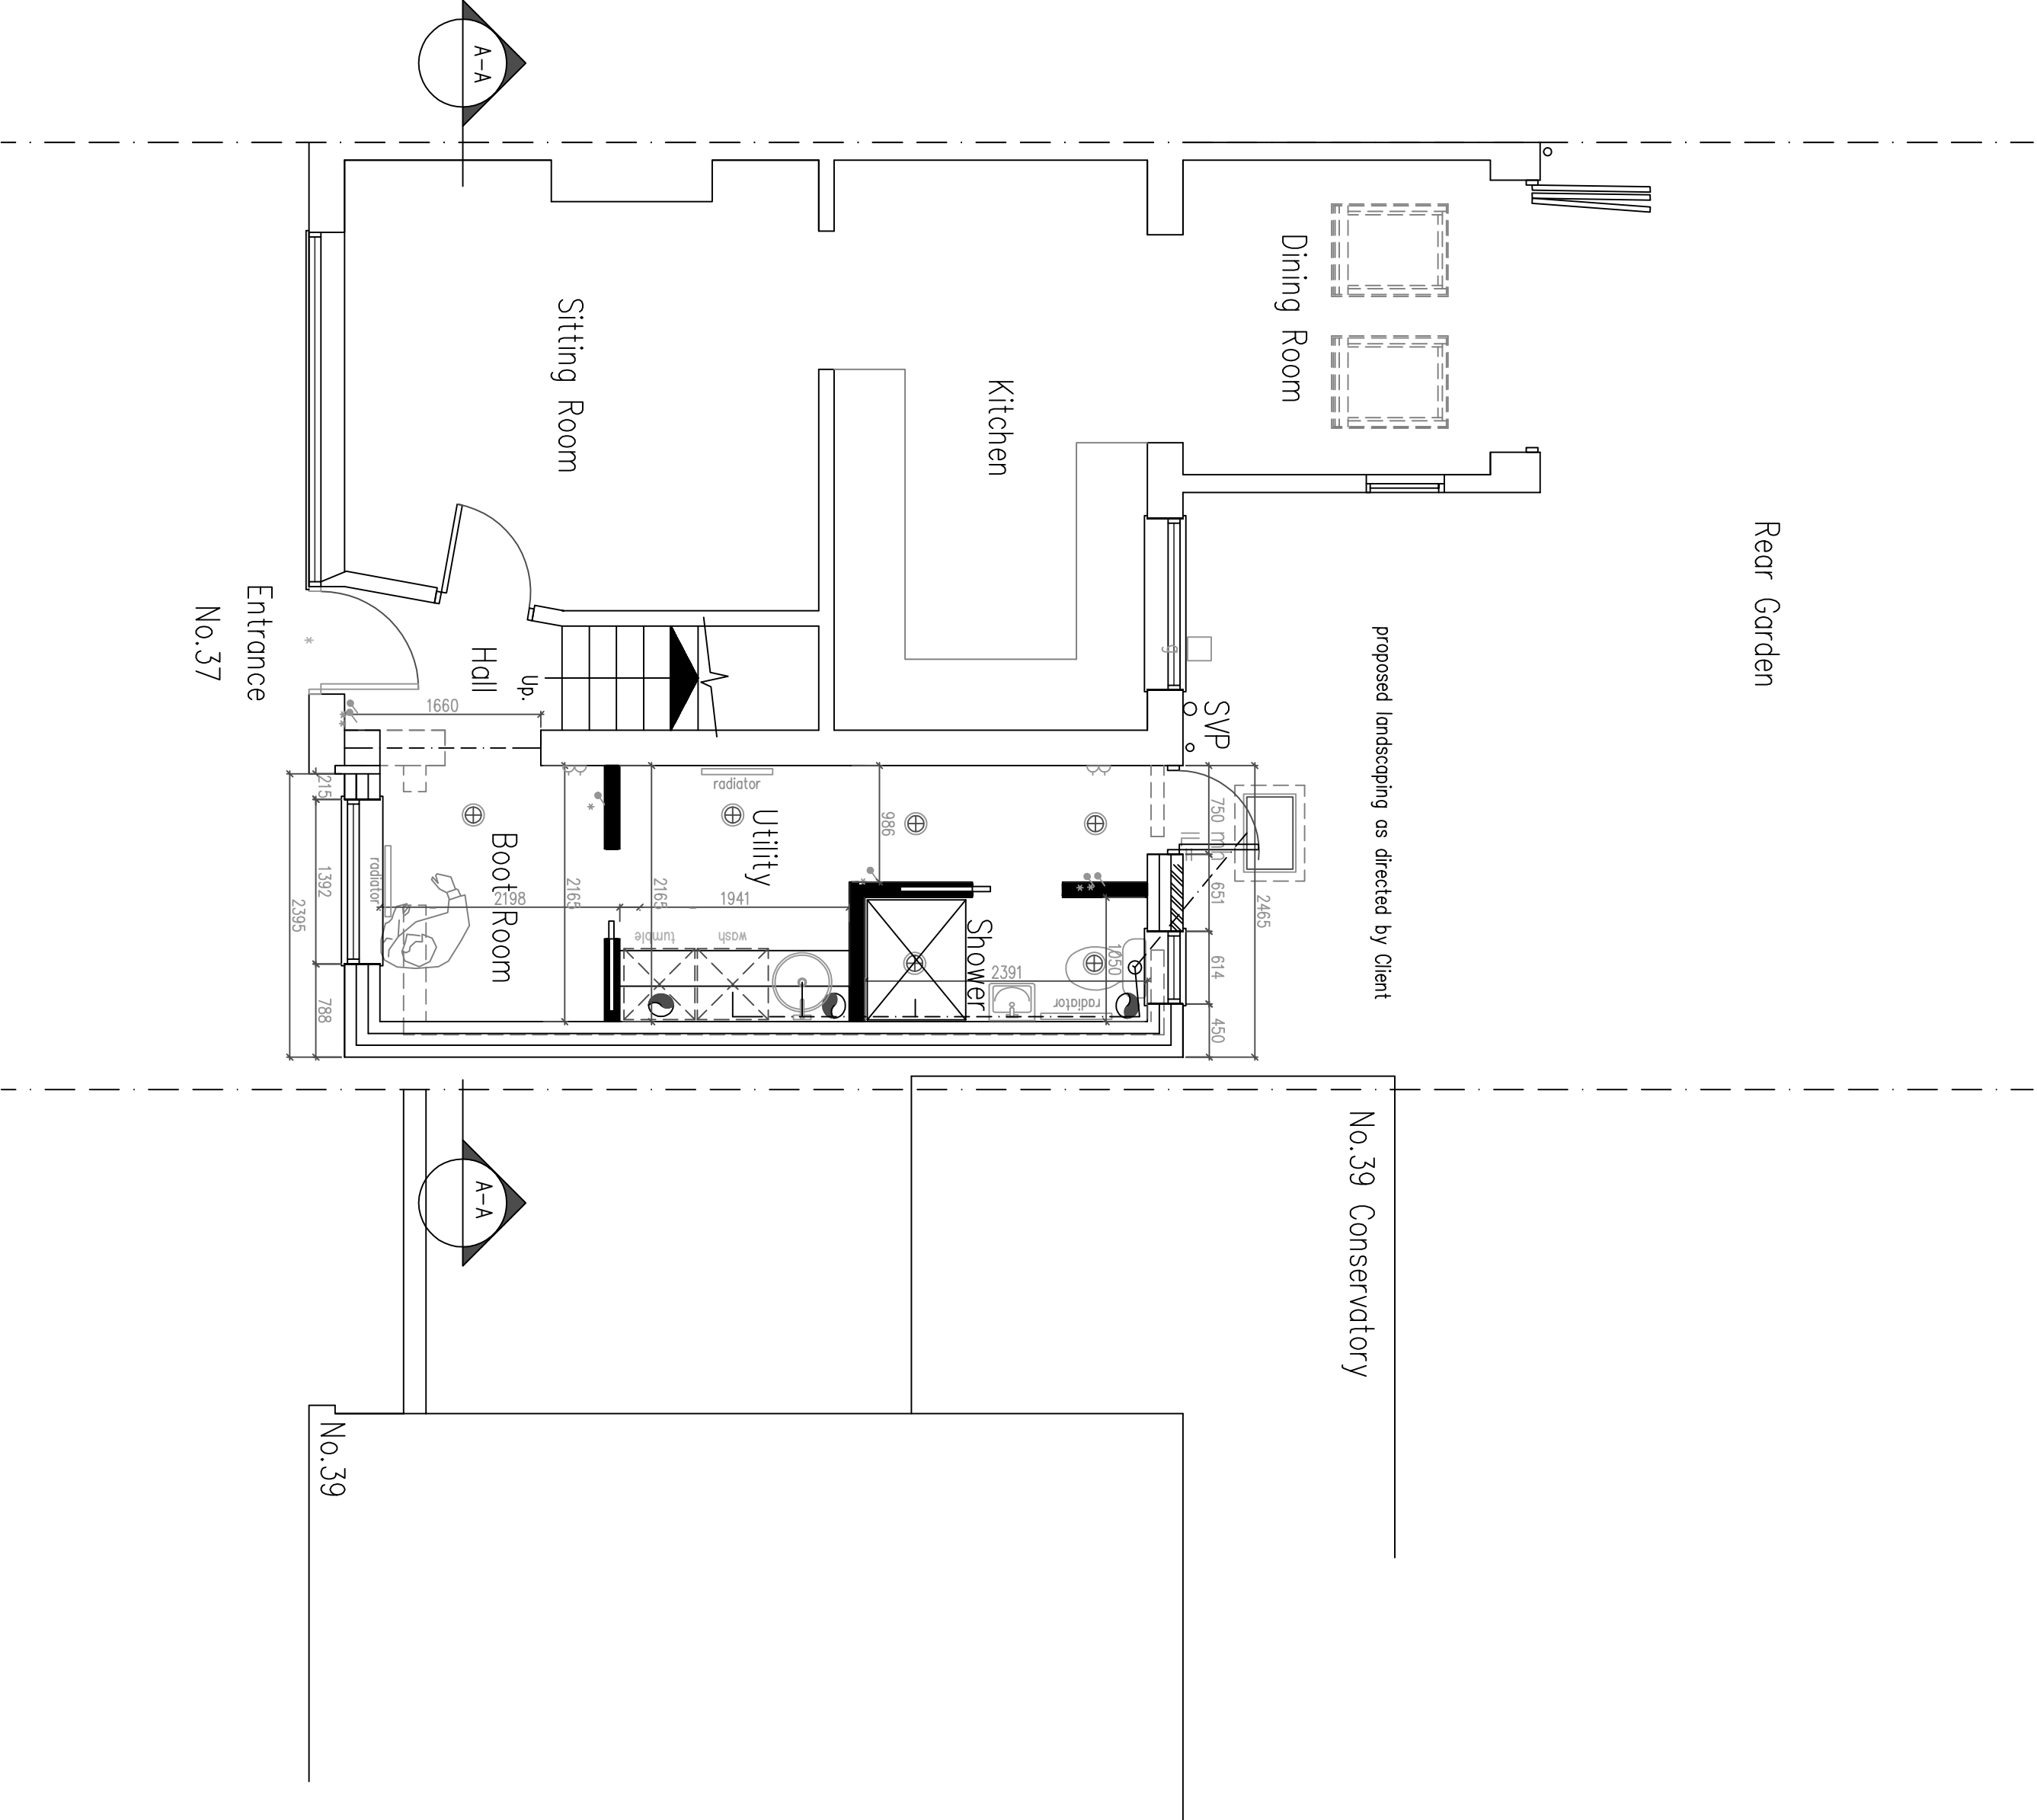

6

Ground Floor Plan

1:50 Scale Bar
1m 2m 3m 4m 5m 6m 7m 8m 9m 10m

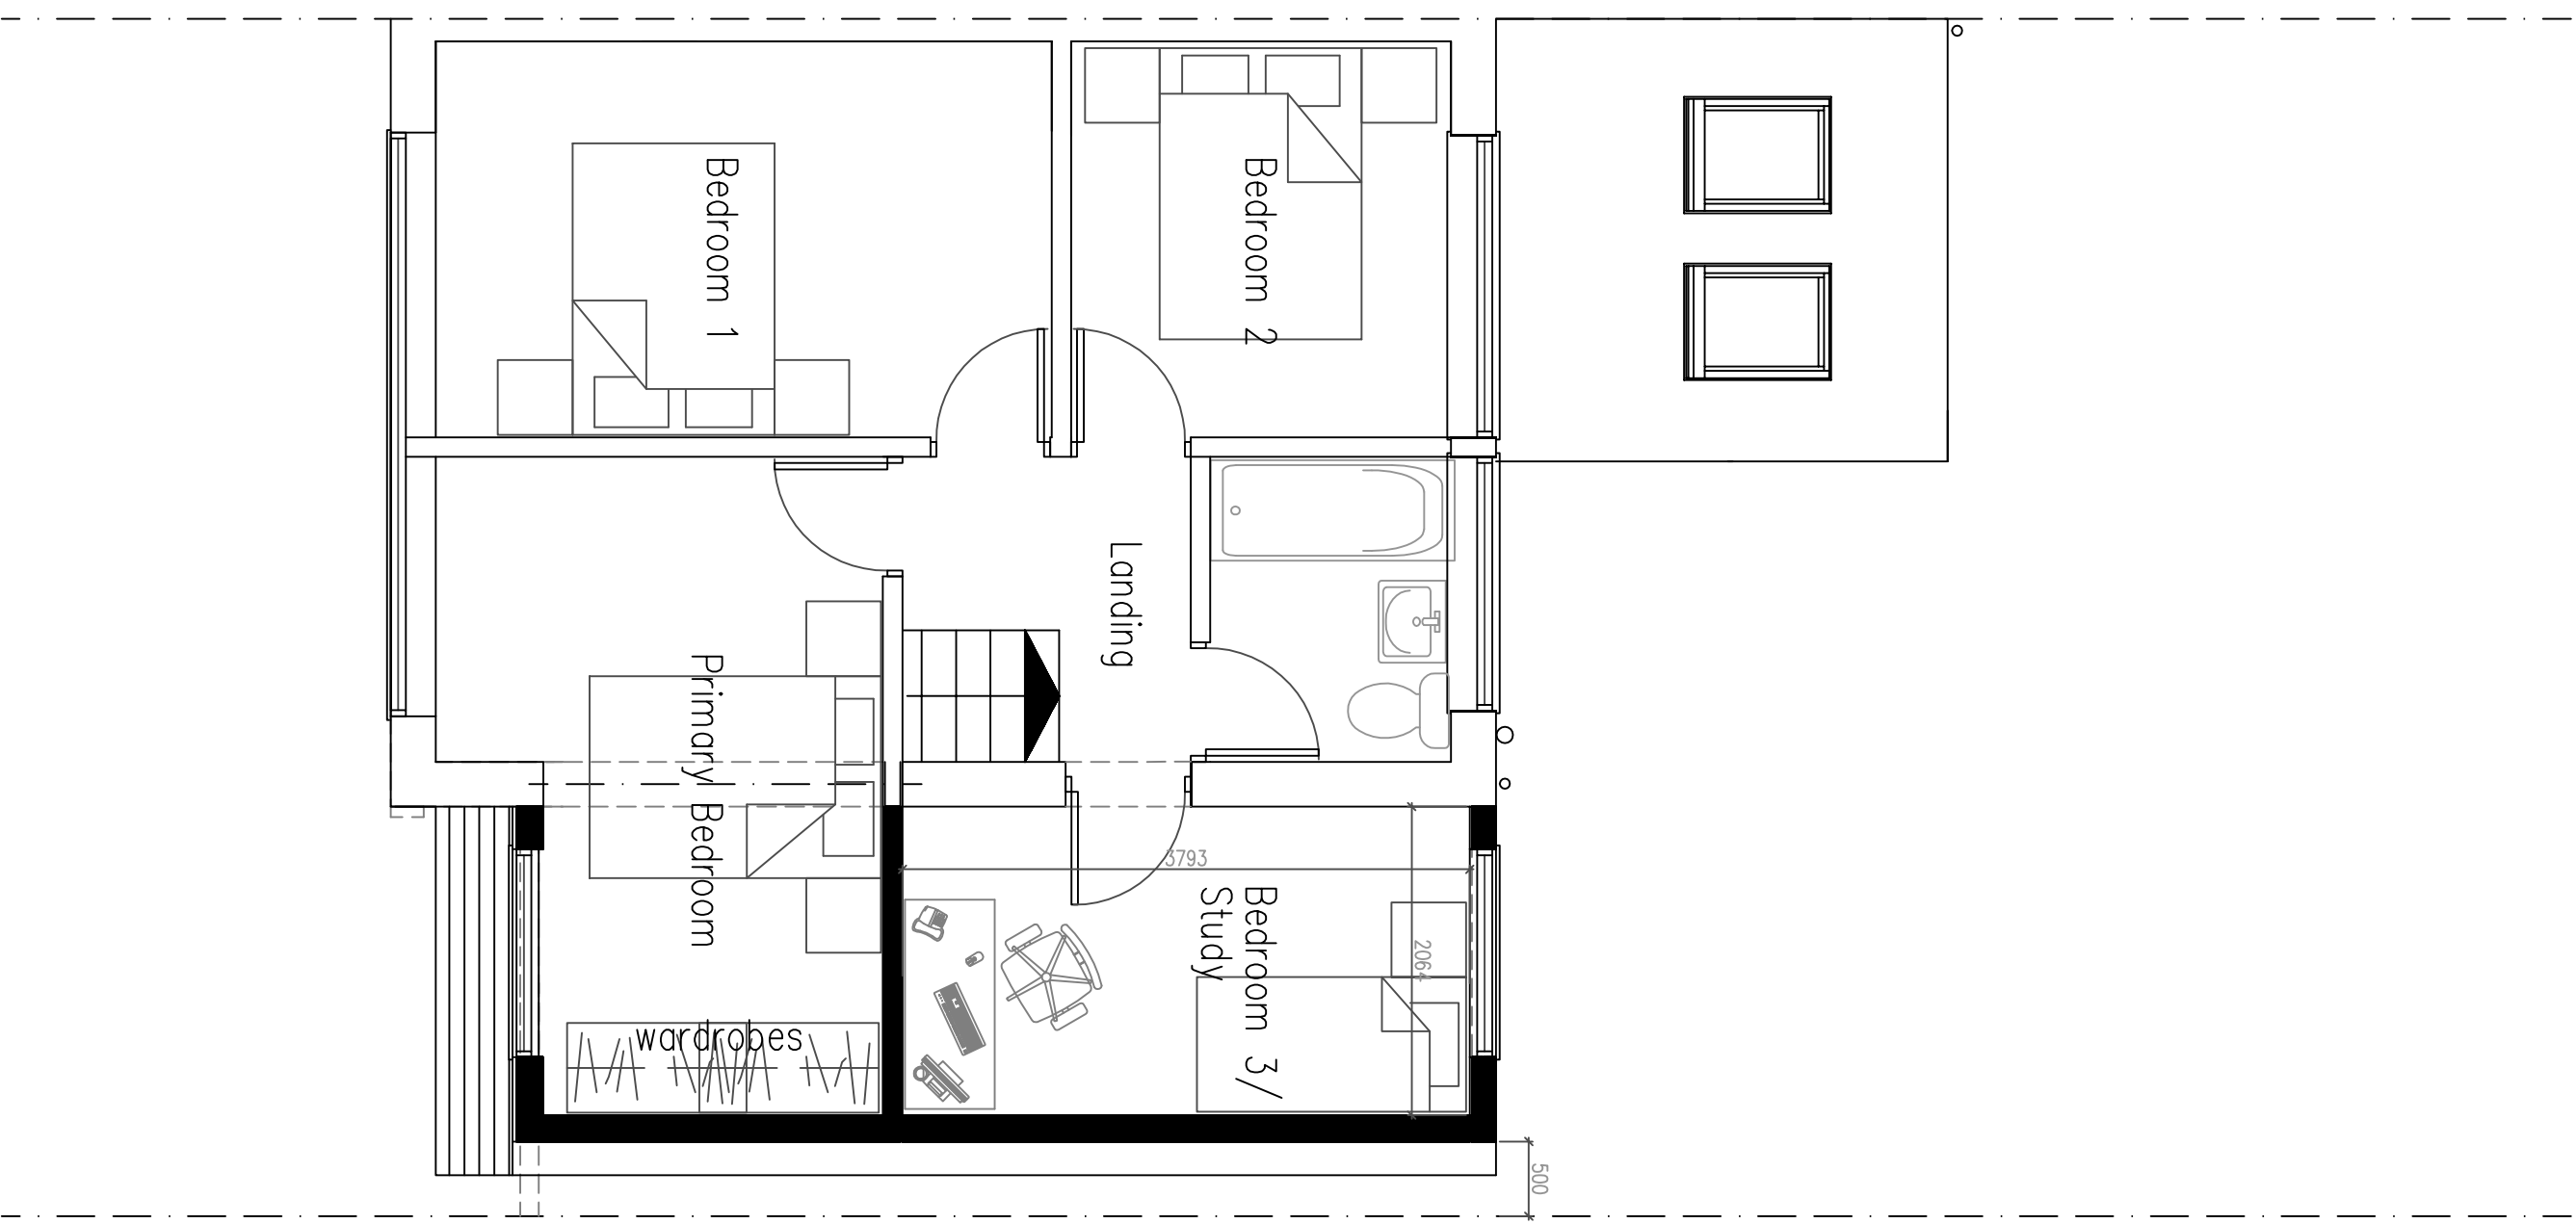


6

First Floor Plan

1:50 Scale Bar
1m 2m 3m 4m 5m 6m 7m 8m 9m 10m

11 Section A-A 1:50 Scale Bar

1m 2m 3m 4m 5m

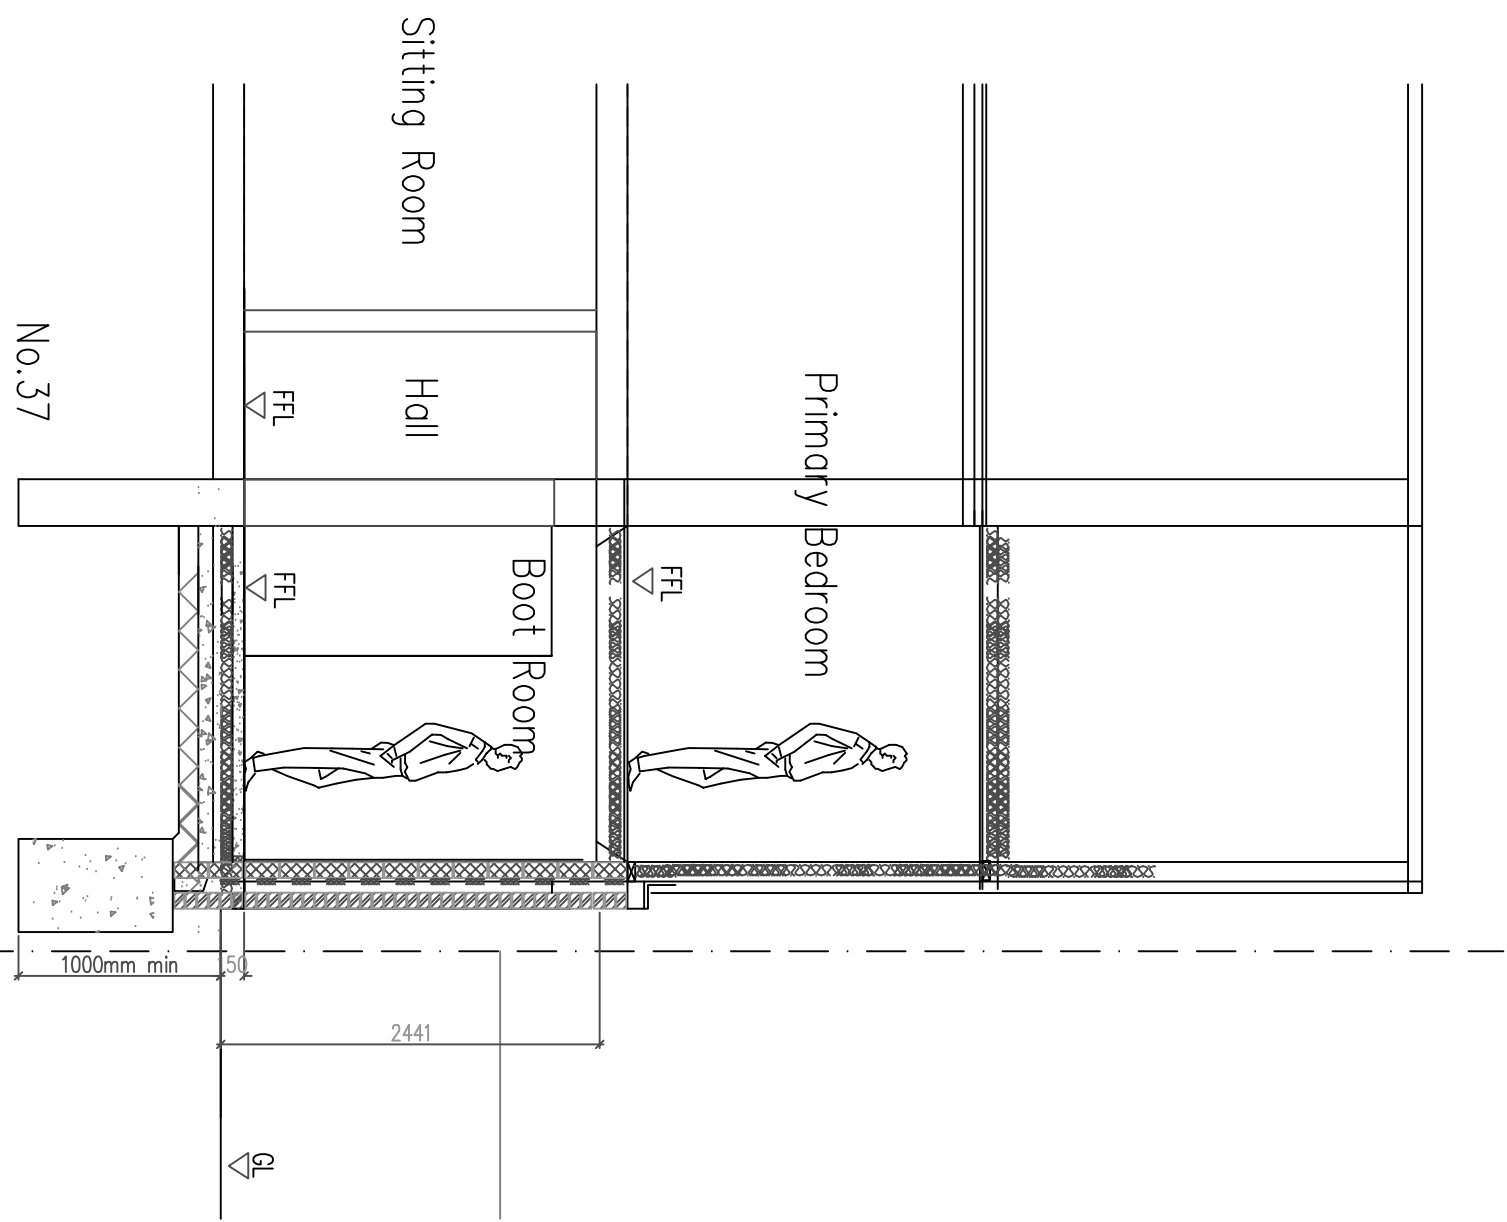

FOUNDATIONS/FLOOR CONSTRUCTION DESIGNED BY
STRUCTURAL ENGINEER TO SUIT LOCAL
SOIL CONDITIONS PROXIMITY TO TREES. ALL TO BE APPROVED BY
BUILDING CONTROL.

NOTE:

FW drain to be located/exposed, pipe diameter/depth of drain the
Flow direction /type of drain IBC by Building control
All to be as Southern Water requirements and Approval

Protect FW pipe through new extension
with 100x65mm concrete plank inlets
For odded FW drain protection – side to be
reinforced with A142 light mesh with 50mm cover
If require depending on condition– replace FW pipe with new
No foundations are permitted within 500mm
of the sewer without Southern Water's
approval.
Foundations are to be taken 150mm below
invert level.
Bridge over sewer with Supreme Concrete
100x140dp PC lintels spanning between new
foundations and the existing external wall.
Depth of sewer is to be confirmed before
commencing works.

Structural Engineer to confirm all beam
layouts and sizes