

Services Key

- SAT – Satellite television aerial point  
CAT5 – data point  
– Denotes pull cord  
– Denotes light switch (2 way)  
– Denotes light switch (1 way)  
– Denotes telephone  
– Denotes television aerial points  
– Denotes double socket  
– Denotes double socket (floor level)  
– Denotes cooker point  
– Denotes spur  
– Denotes external water tap  
– Denotes radiator  
– Denotes PIR detector  
– Denotes extractor fan  
– Denotes smoke detector  
– Denotes heat detector  
– Denotes meter  
– Denotes wall light  
– Denotes ceiling rose  
– Denotes spotlight  
– Denotes fluorescent tube

Notes:  
Final number of sockets, lights, radiators, positions etc to be agreed with the Client.  
Contractor to assess existing electrical system and meter/distribution board and advise of any additional work required due to new works.

Structural Engineer to confirm all beam layouts and sizes

DO NOT SCALE FROM THIS DRAWING EXCEPT FOR PLANNING AS PHOTOCOPIES WILL BE SUBJECT TO DISTORTION DRAWINGS TO BE READ IN CONJUNCTION WITH ALL OTHER DRAWINGS. 3 SEPARATE ENGINEER'S CONTRACT ANY DISCREPANCIES MUST BE BROUGHT TO THE ATTENTION OF THE ARCHITECT IMMEDIATELY. THE CONTRACTOR MUST VERIFY ALL DIMENSIONS BY SITE MEASUREMENT BEFORE ORDERING MATERIALS OR MANUFACTURING COMPONENTS. SUBSTITUTE MATERIALS & PRODUCTS TO THOSE SPECIFIED IN THIS DRAWING SHALL BE OF EQUAL OR HIGHER PERFORMANCE AND NOT IN CONFLICT WITH OTHER ELEMENTS. FOUNDATIONS/FLOOR CONSTRUCTION DESIGNED BY STRUCTURAL ENGINEER TO SUIT LOCAL SOIL CONDITIONS PROXIMITY TO TREES ETC. ALL TO BE APPROVED BY BUILDING CONTROL.

Project:  
Proposed Extensions and Internal Alterations At:  
69 Raleigh Crescent  
Worthing  
West Sussex

Drawing title:

Plans & Elevations As Proposed

Client:  
Chris Toolan


© Copyright of:  
Architectural & Planning Services  
7 Errington Rd  
Shoreham By Sea  
West Sussex  
BN43 5ND  
**BJW**  
01273 441009  
e-mail: bjw@bjwarchitectural.co.uk  
website: bjwarchitectural.co.uk

Scale:  
1:50 1:100  
Paper size  
A1

Date:  
22.10.2025  
Drawn:  
BJW


Dwg No.  
02  
Rev'n  
F

Note: All dimensions to be checked on site.

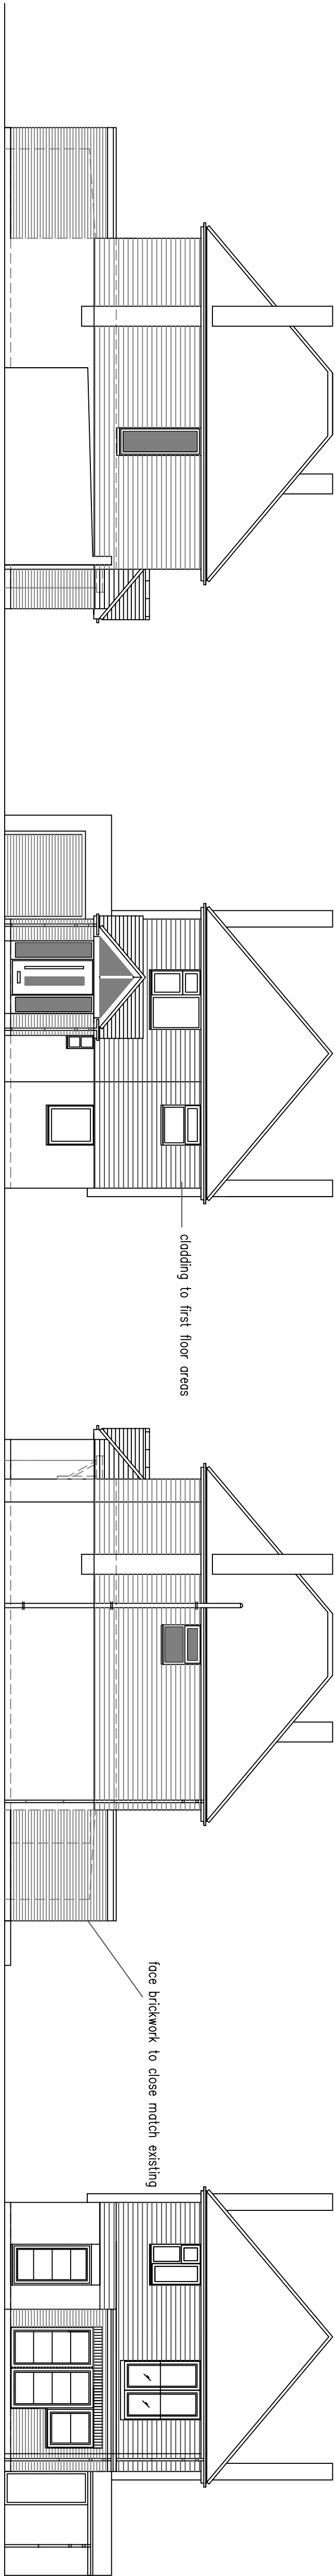


East Facing Side Elevation

1m 2m 3m 4m 5m 6m 7m 8m 9m 10m  
1:100 Scale Bar

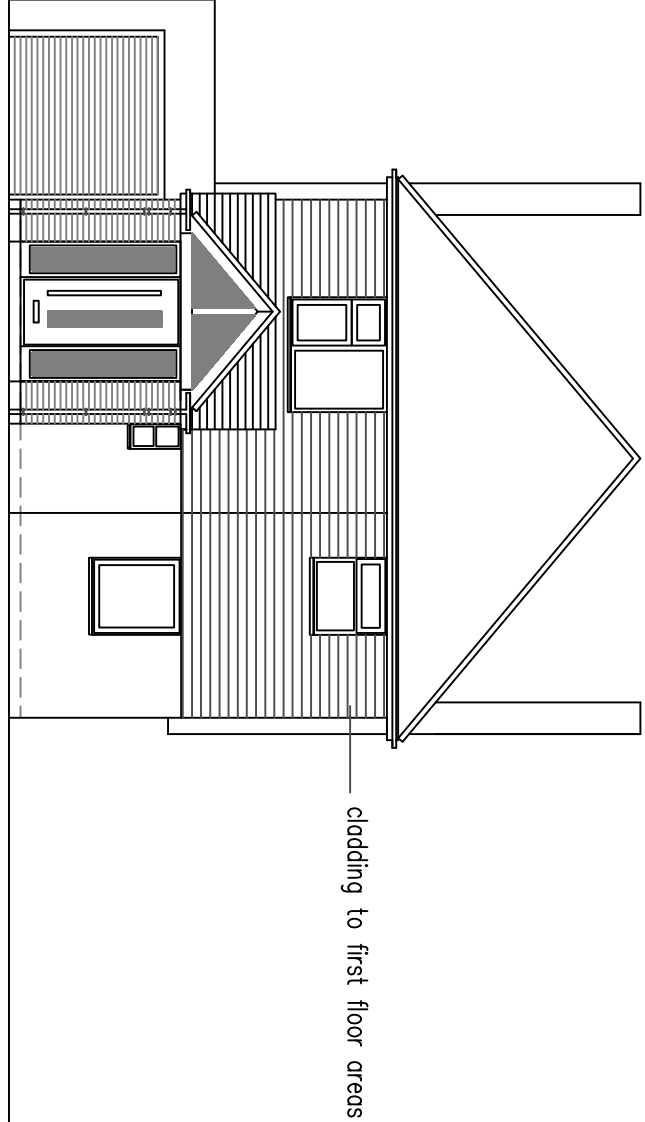


North Facing Front Elevation

1m 2m 3m 4m 5m 6m 7m 8m 9m 10m  
1:100 Scale Bar

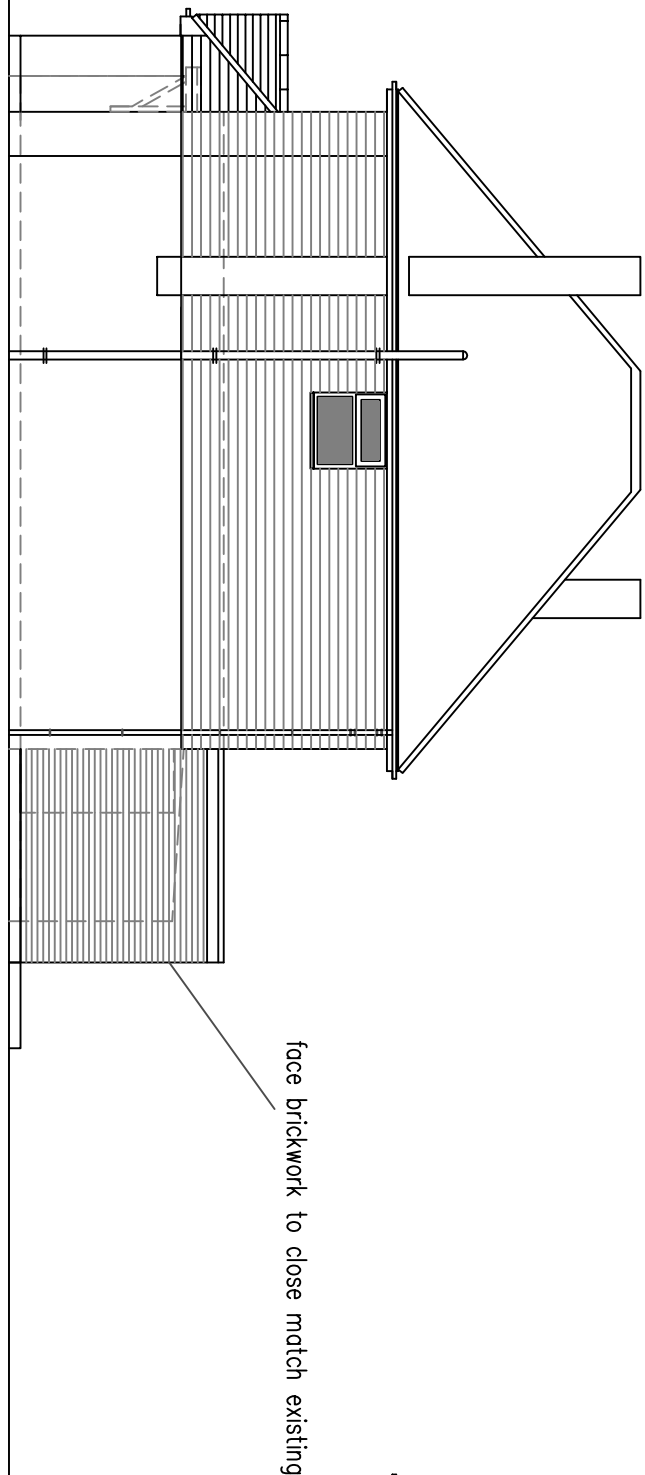

West Facing Side Elevation

1m 2m 3m 4m 5m 6m 7m 8m 9m 10m  
1:100 Scale Bar

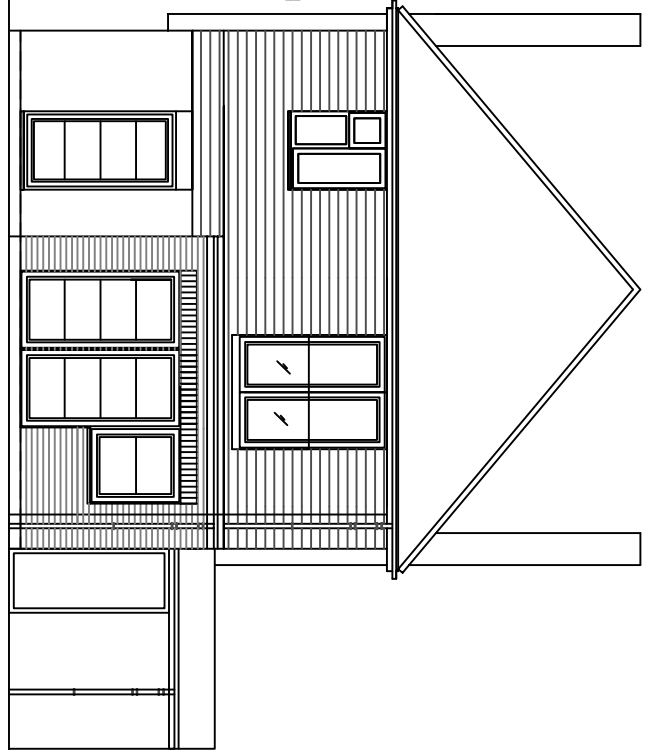

South Facing Rear Elevation

1m 2m 3m 4m 5m 6m 7m 8m 9m 10m  
1:100 Scale Bar


NOTE:

FW drain to be located/possed, pipe diameter/depth of drain the Flow direction /type of drain TBC by Building control  
All to be as Southern Water requirements and Approval

Protect FW pipe through new extension with 100x65mm concrete plank inlets  
For added FW drain protection – slab to be reinforced with A142 light mesh with 50mm cover  
If require depending on condition– replace FW pipe with new  
No foundations are permitted within 500mm of the sewer without Southern Water's approval.


Foundations are to be taken 150mm below Invert level.  
Bridge over sewer with Supreme Concrete 100x140dp PC inlets spanning between new foundations and the existing external wall.  
Depth of sewer is to be confirmed before commencing works.

Structural Engineer to confirm all beam layouts and sizes

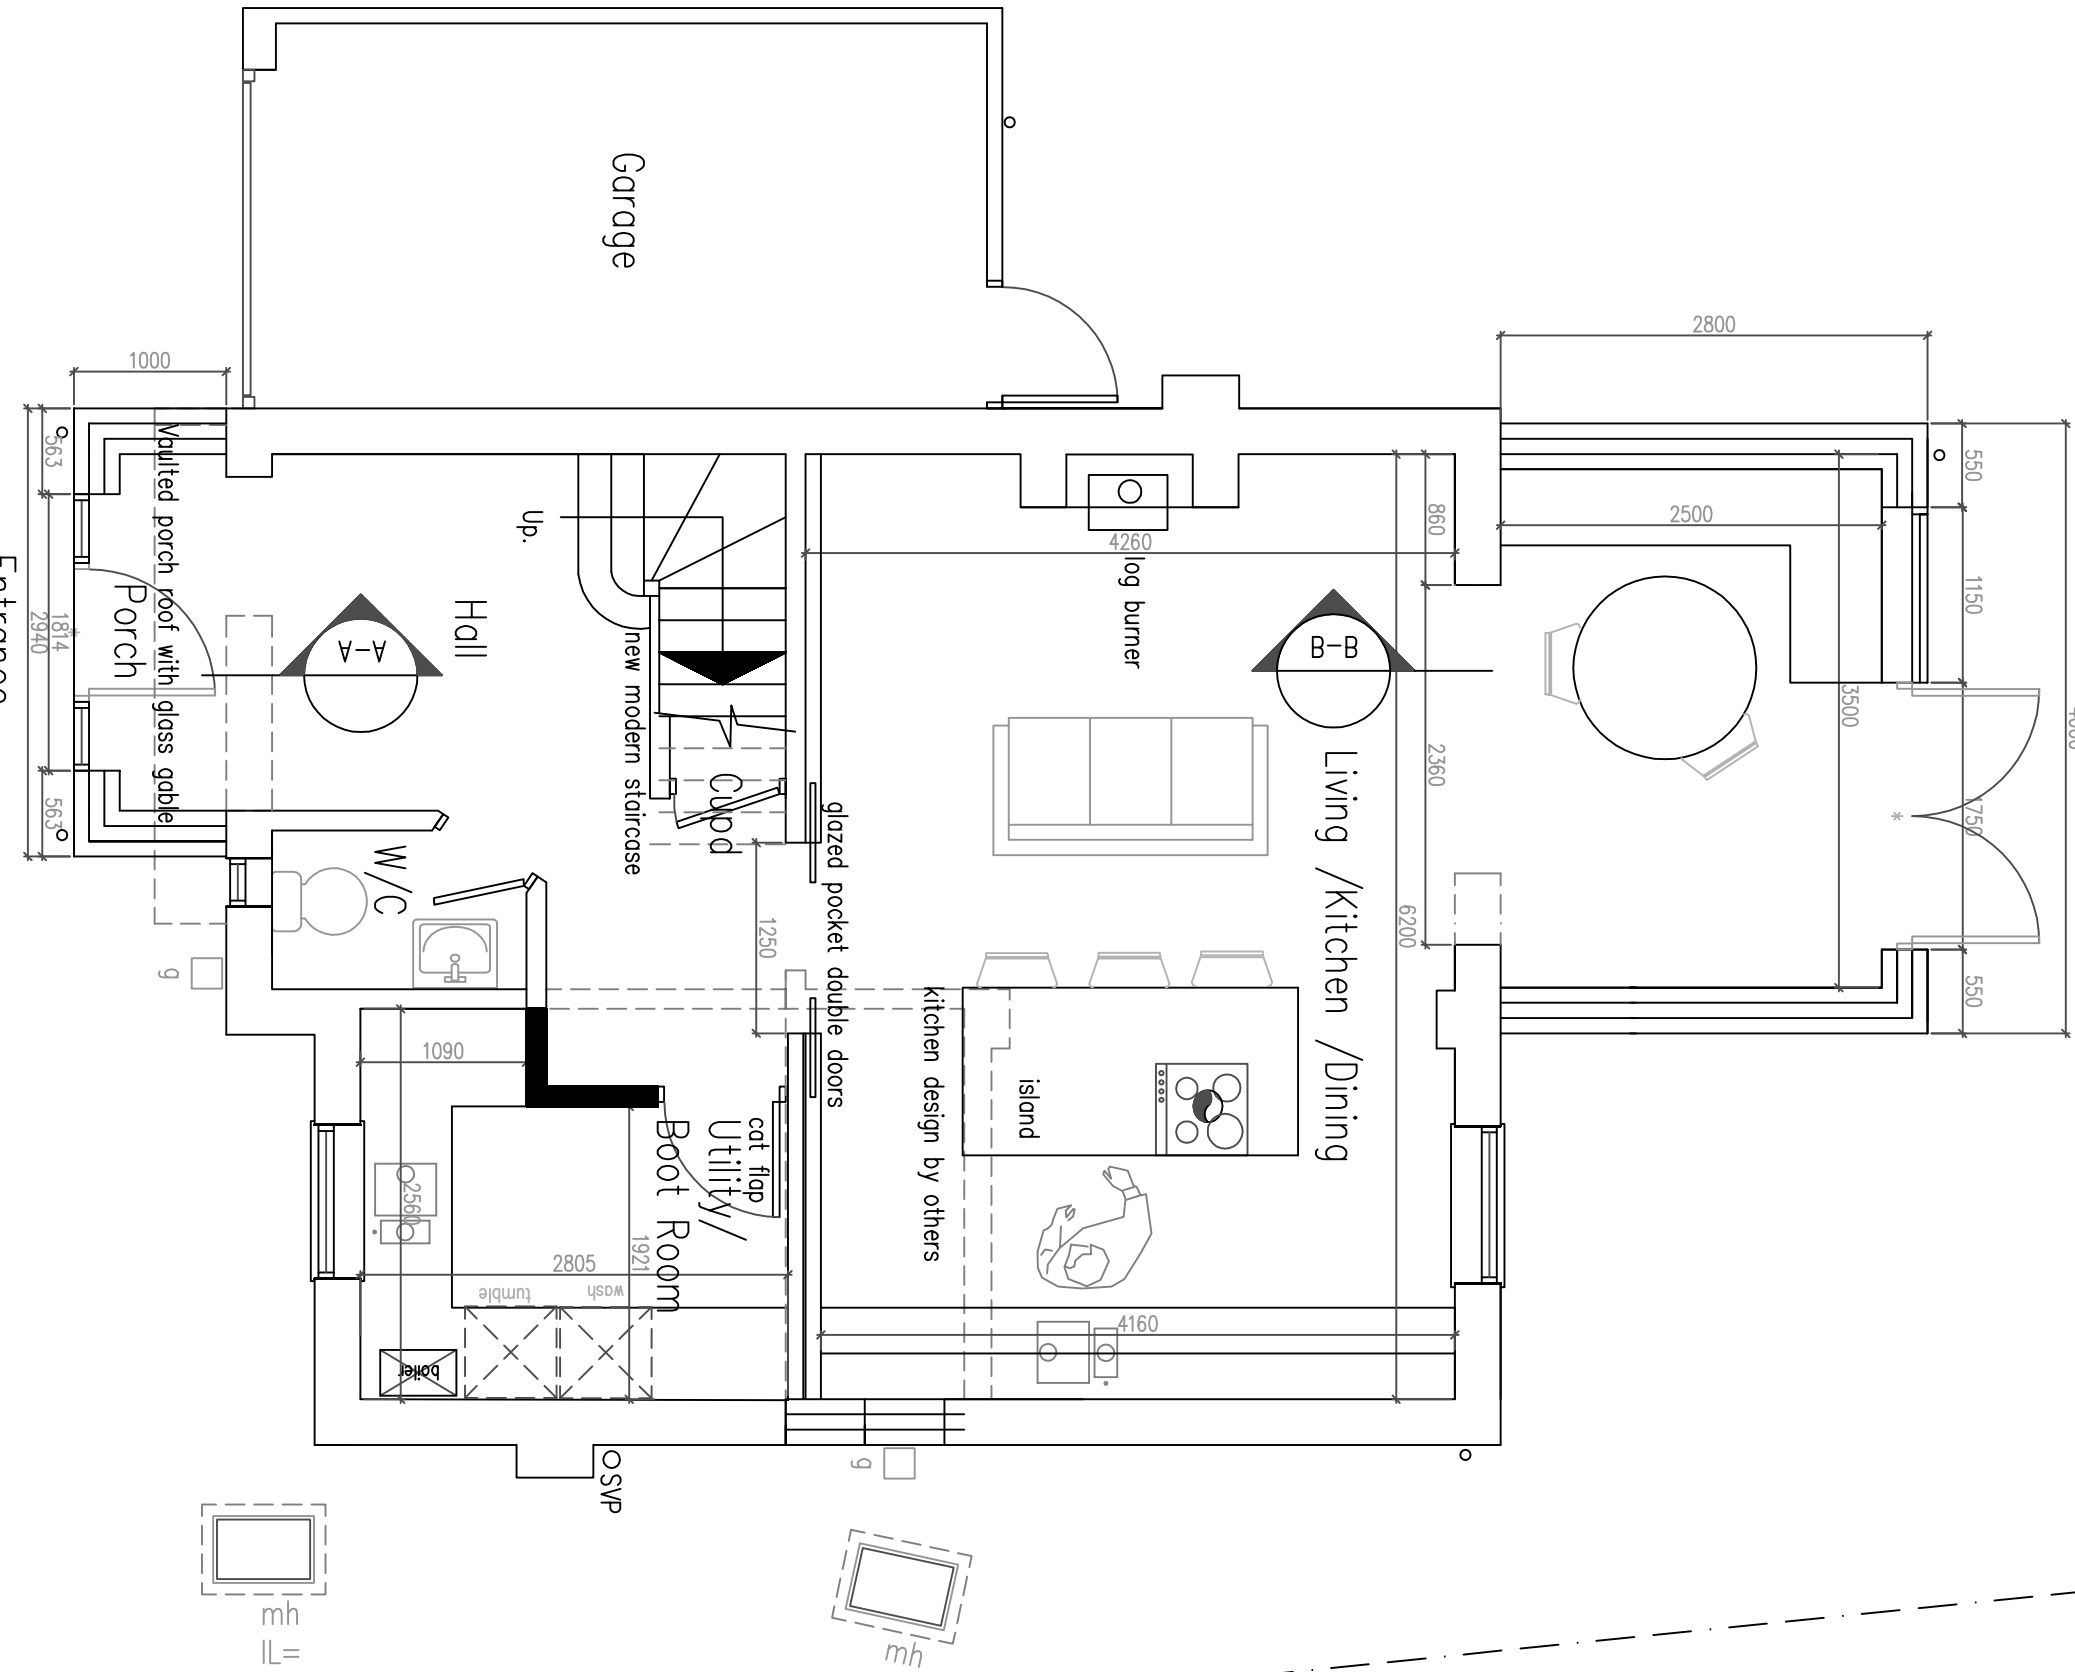

Ground Floor Plan

1:50 Scale Bar  
1m 2m 3m 4m 5m 6m 7m 8m 9m 10m

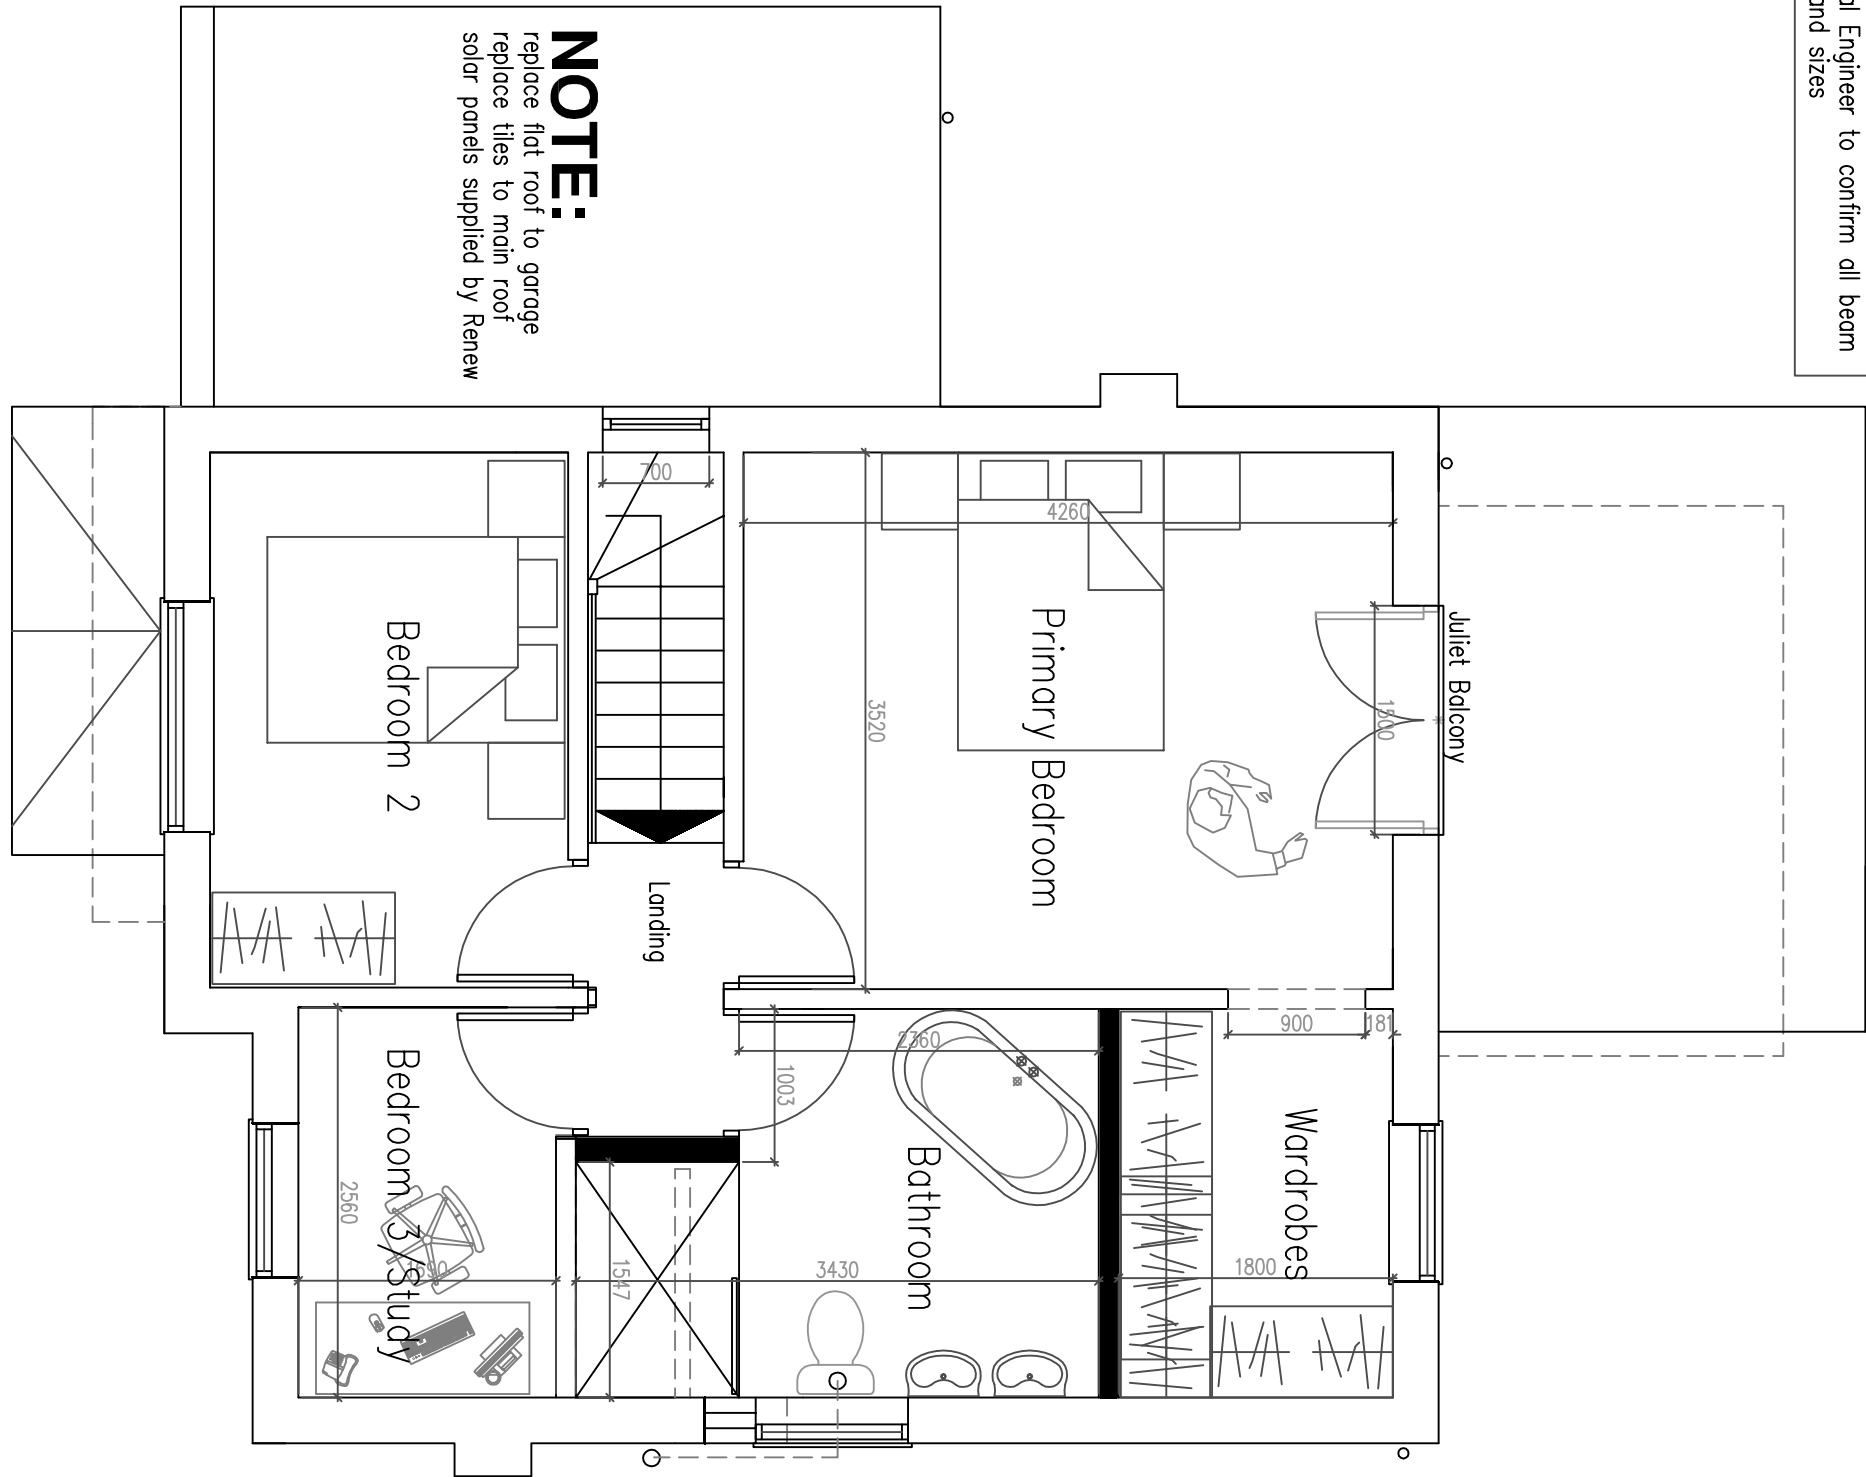


First Floor Plan

1:50 Scale Bar  
1m 2m 3m 4m 5m 6m 7m 8m 9m 10m



SECTION A-A

1:50 Scale Bar  
1m 2m 3m 4m 5m 6m 7m 8m 9m 10m

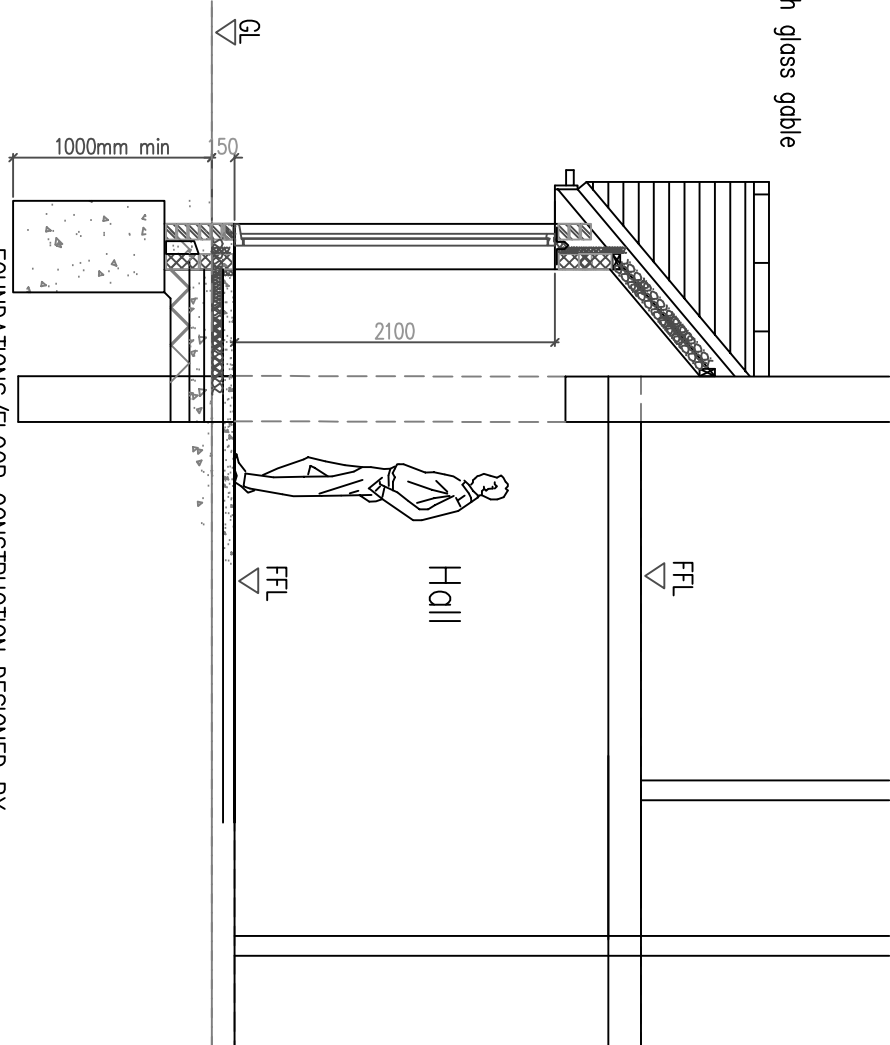

SECTION B-B

1:50 Scale Bar  
1m 2m 3m 4m 5m 6m 7m 8m 9m 10m

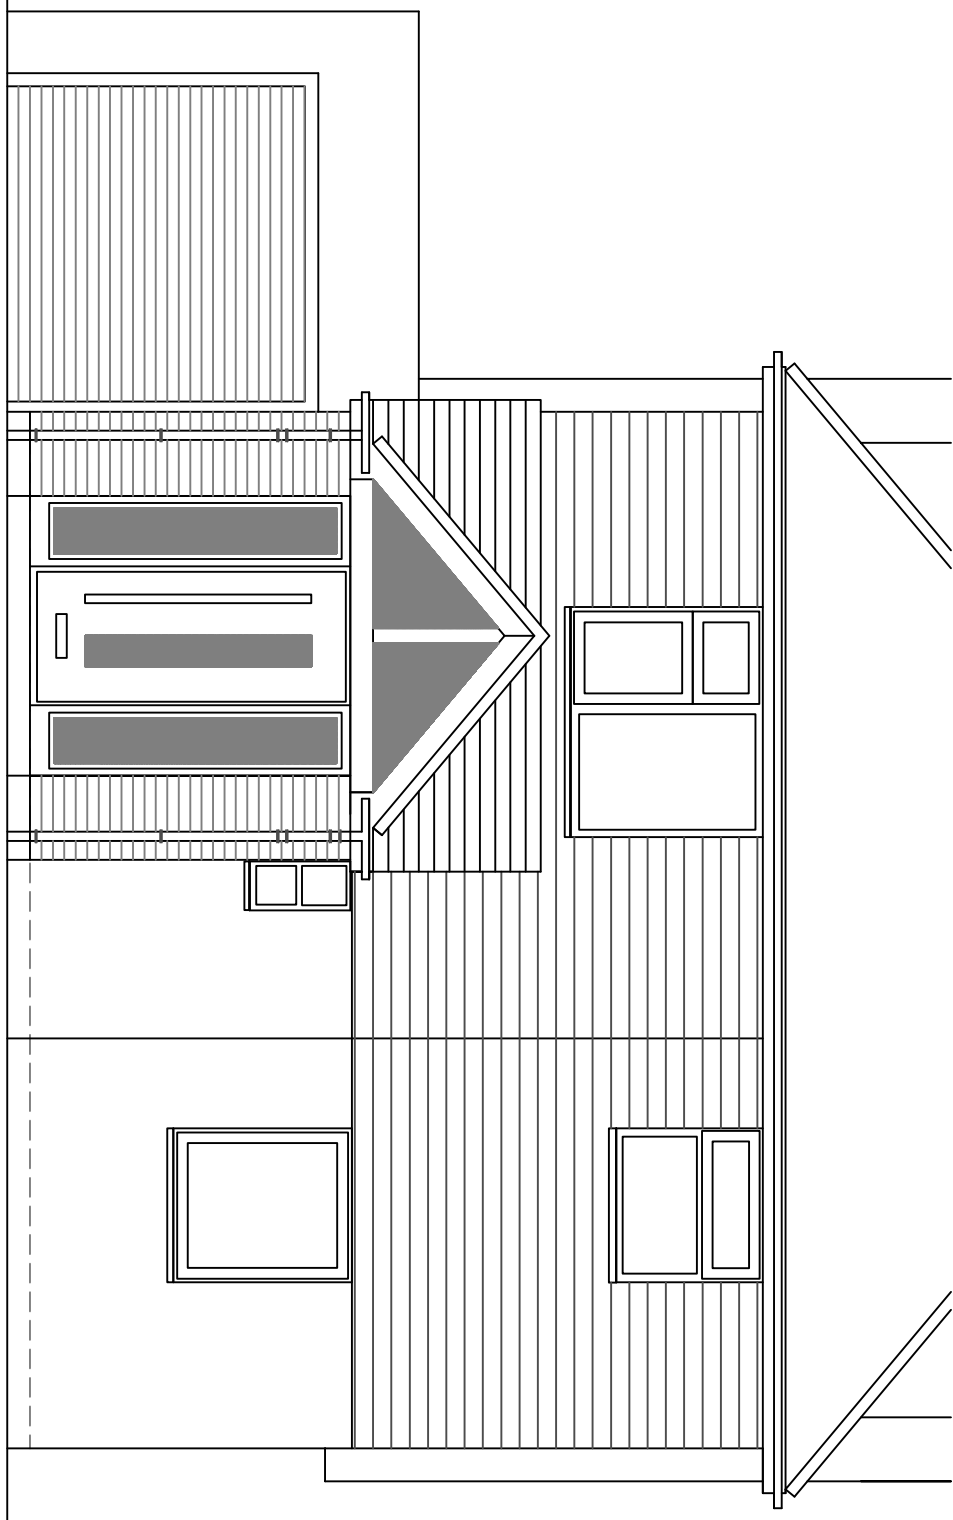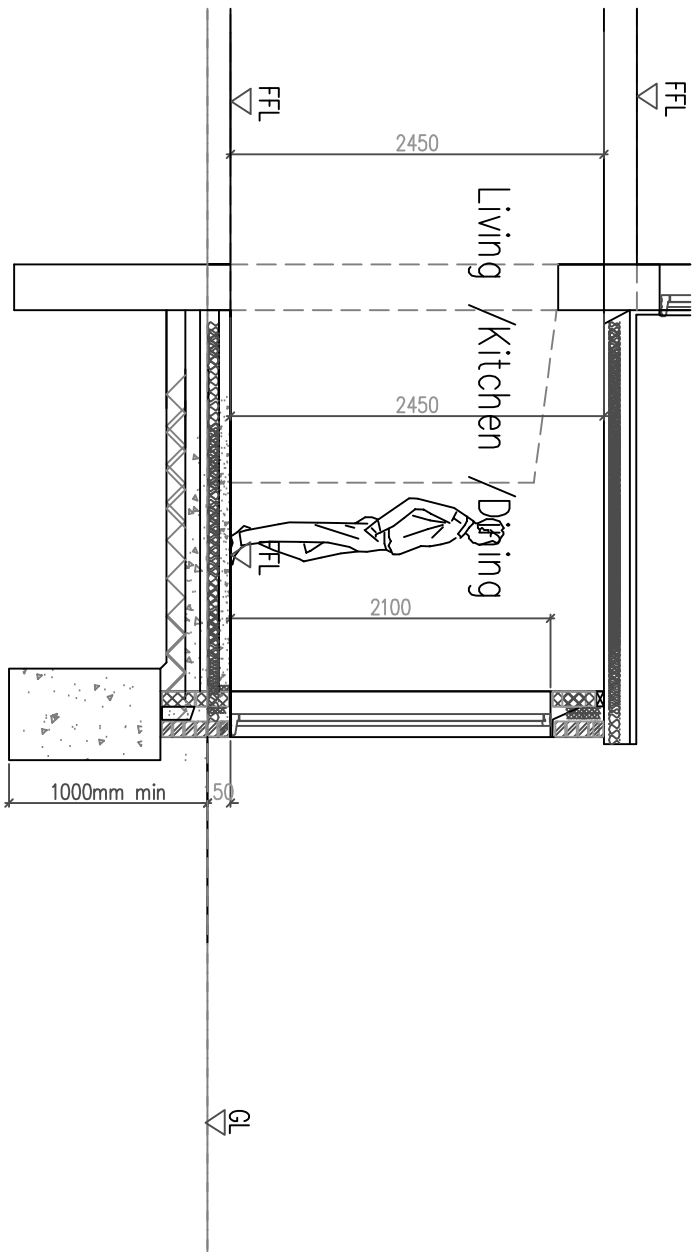

North Facing Front Elevation 1:50

1m 2m 3m 4m 5m 6m 7m 8m 9m 10m