
 
 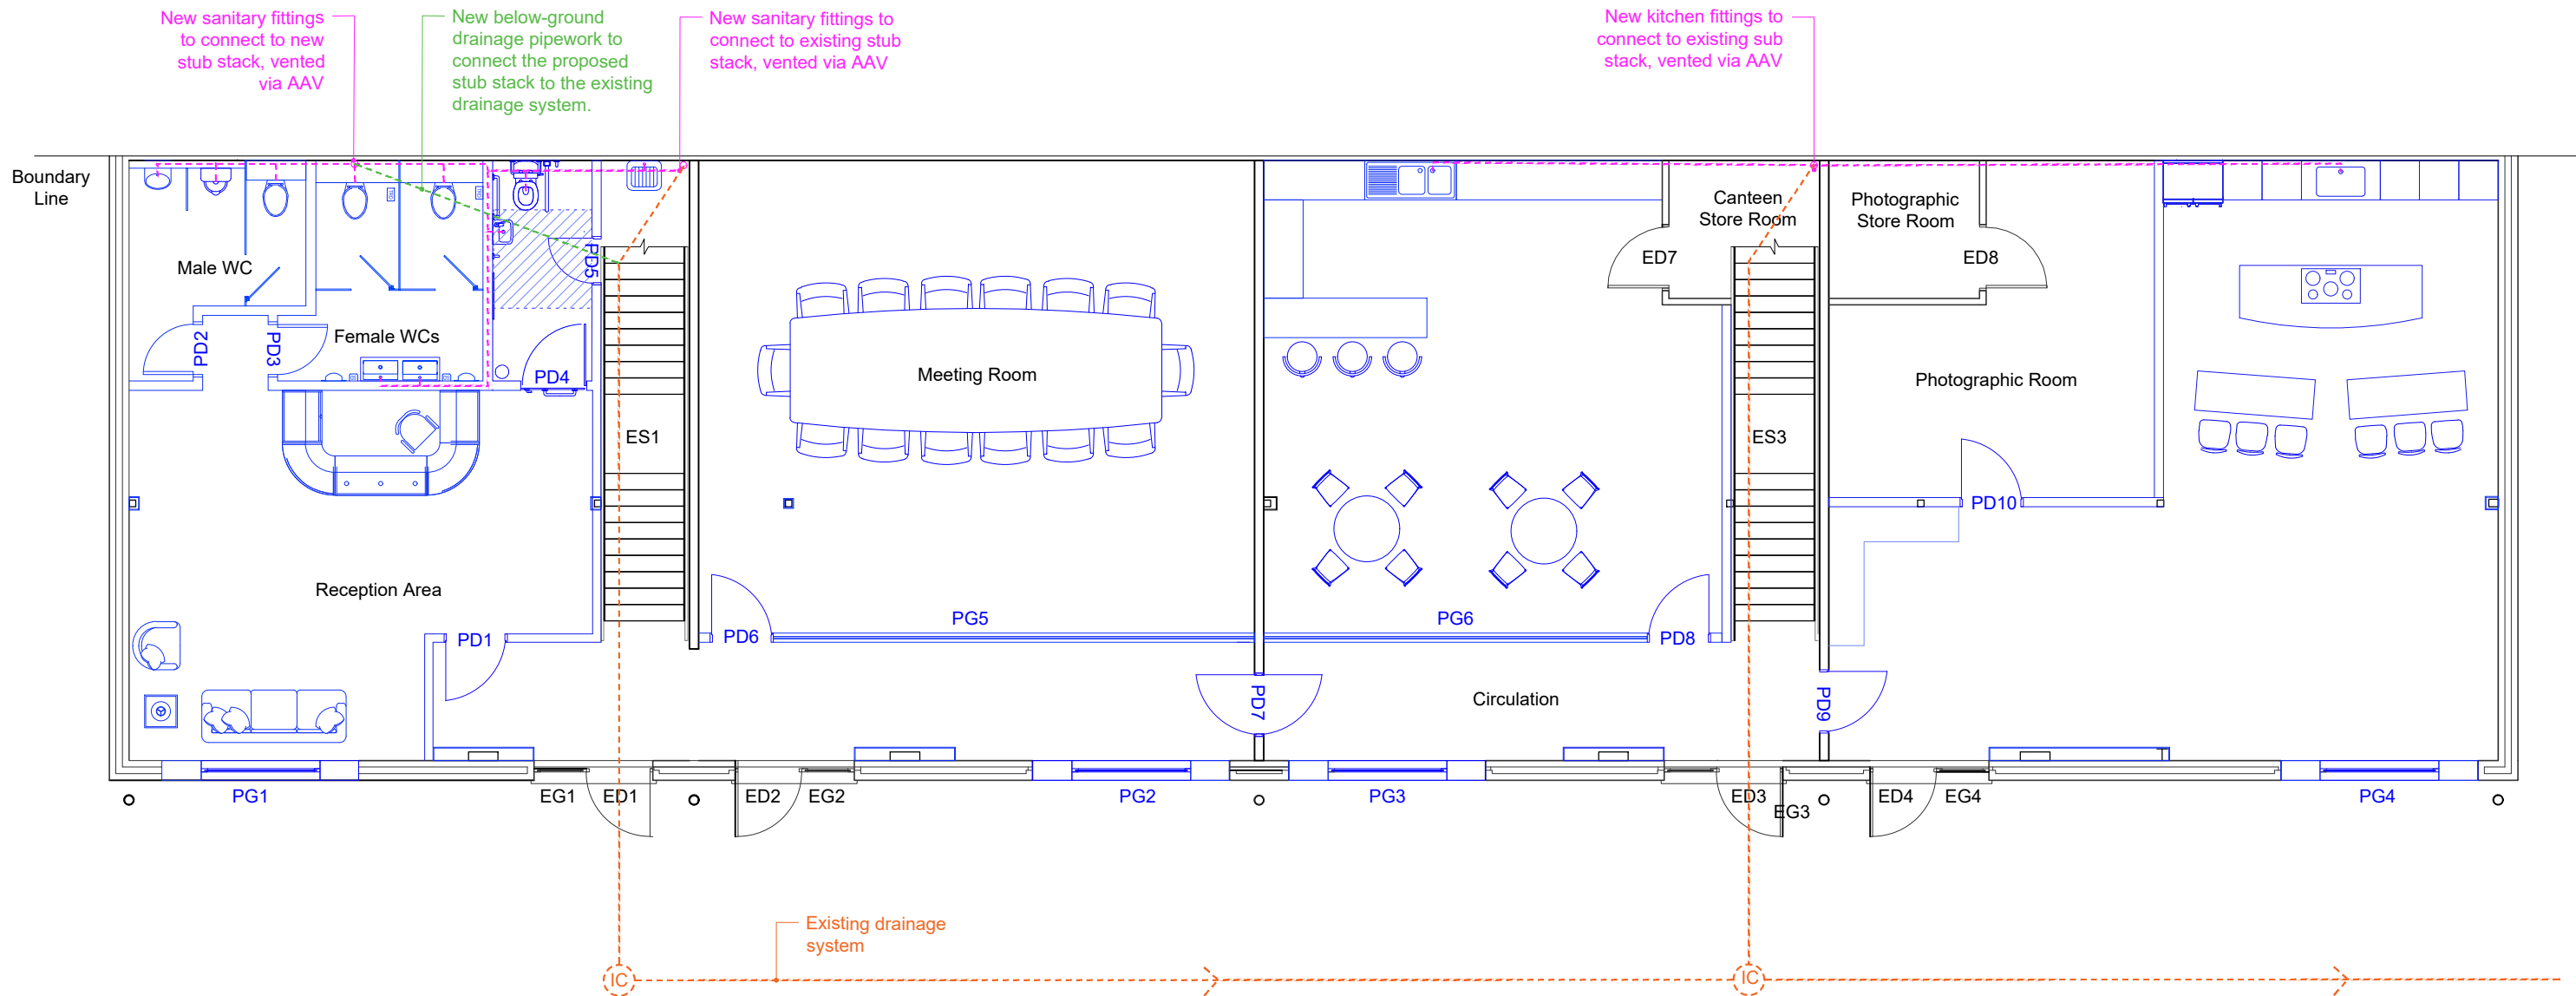




Scale in Metres



Notes:

DO NOT SCALE FROM THIS DRAWING. Use figured dimensions only.

This drawing is the copyright of MacConvilles Ltd and may be reproduced either in hard copy or electronic format for the internal use of the recipient in connection with this project only.

This drawing may not be reproduced further nor amended or extracted from nor used for any other purpose without the prior written consent of MacConvilles Ltd.

This drawing must be read in conjunction with all other related drawings and documentation. Any discrepancy in either must be reported immediately to MacConvilles Ltd.

It is the contractor's responsibility to check all dimensions on site, any discrepancy to be reported immediately to MacConvilles Ltd.

Details are representative only, size and final setting out to be verified on site, and subject to confirmation by relevant specialist subcontractor.

Full original record copies of issued drawings are kept at MacConvilles Ltd.

MacConvilles Ltd declares its moral rights to be identified as the authors of this drawing and any architectural work carried out in this project.

Drawing Status

FOR PLANNING

Rev	Description	By	Date
P1	First Issue	DC	23.03.2026

 **MacConvilles**

Office 2.31,
4500 Parkway,
Solent Business Park,
Whiteley,
Fareham,
PO15 7AZ
T +44 (0) 2381980021
E mail@macconvilles.com
W www.macconvilles.com



Client Electronic Temperature Instruments Ltd			
Project Title Units 2-5 Glenmore Business Park			
Drawing Title Proposed Ground Floor Drainage Plan			
Scale @ A3 1:100	Drawn DC	Checked PB	Revision Date 23.03.2026
Drawing Details Project Originator System Level Type Role Number Revision 27014 - MAC - XX -00 -DR - B - 0304 - P1			