


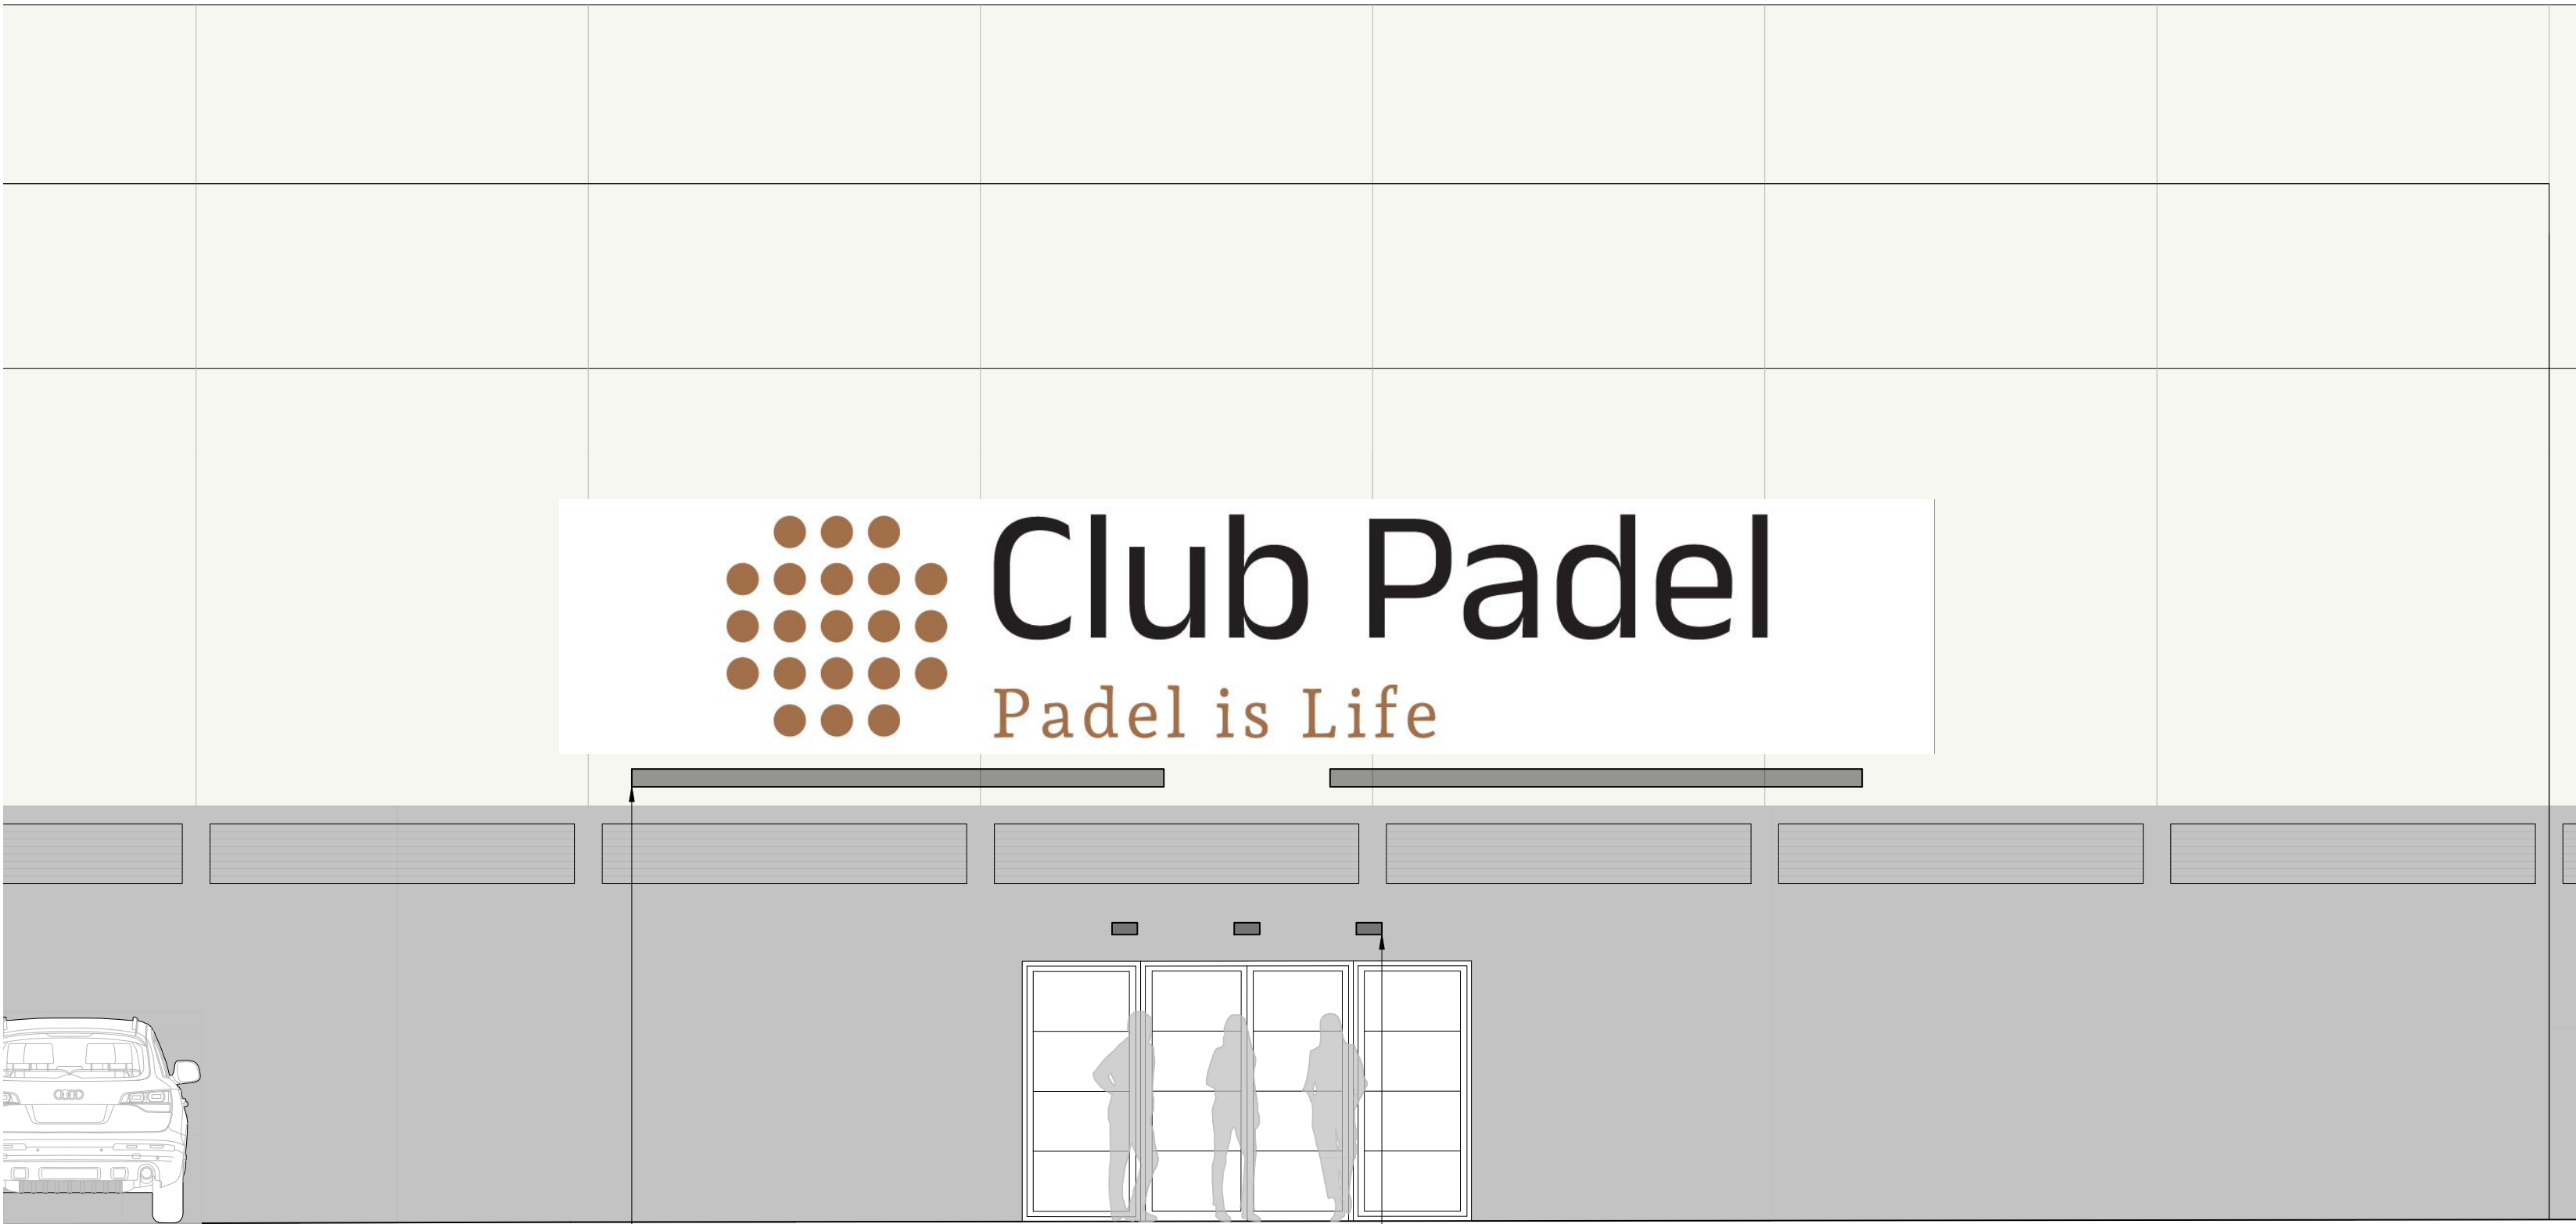

2no 4572mm 3000K warm white LED uplights in black

3no 215mm 3000K warm white LED spots

Part North Elevation 1:50



Signage uplighters (x2)



Entrance Lights (x3)

amendments		bpm Architectural Services Ltd.		
client	Club Padel			
project	Aggregate Yard Fishermans Wharf Brighton Road Shoreham BN43 6RE			
project ref.	3102	Drawing No.	100	
drawing title	Proposed Lighting			
drawn by	J Boys			
date	Feb 26	scale	1:50@ A1	
www.bpmnet.co.uk info@bpmnet.co.uk				
Do not scale off drawing, check all goods materials workmanship to all dimensions on site before all conform with current building regs work is commenced BSS and COP's				